


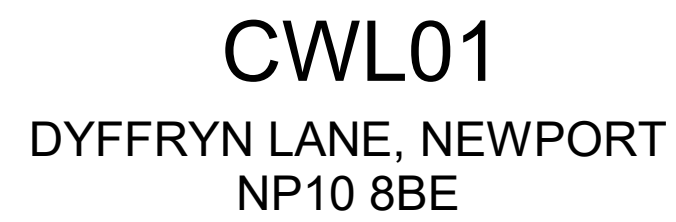

PINNACLE
CONSULTING ENGINEERS



Design	RL
Drawn	SAY
Checked	JJ
Date	19/02/2025
Company Project No.	C2268163
M.S. Project No.	P.17663


MICROSOFT		Date
CUSTOMER		
	LEVI HOLLAND	
Microsoft Design Manager	MARK GLEESON	
Microsoft Electrical Engineer	GERARD CUNHAM	
Microsoft Business Engineer	ANDY LAYER	
Microsoft Mechanical Manager	PATRICK DHERTY/OLAN ROWAN/ PROMOTIONS MANAGER	
CSA	JOULI PARLAMENTAL RAJ / MARK KELLY	
Telecom	DAVID BEADLE	
Security Manager	DERRECK GORMAN	
Environmental		

Project Planner	Date
Project Manager	
Senior Project Manager	
Development Manager	
Project Manager	
Quality Control Reviewer	
Quality Control FF&E	

Rev	Date	Description
A	06.09.24	IFC
B	01.11.24	IFC - DCN09 - CWL02 Omission
C	20.11.24	UPDATED FOR SAB APPLICATION
D	21.02.25	SAB UPDATES
E	28.02.25	IFC UPDATES


Key Plan

SITE NORTH

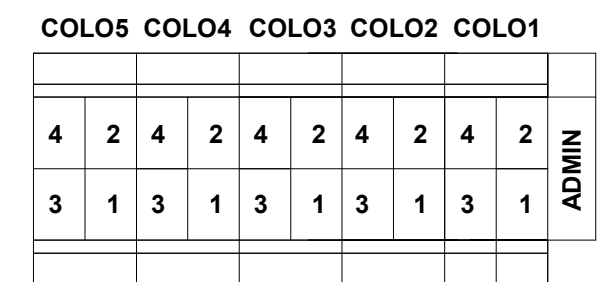

Sheet Title/Number

CWL01-C-D-01-0

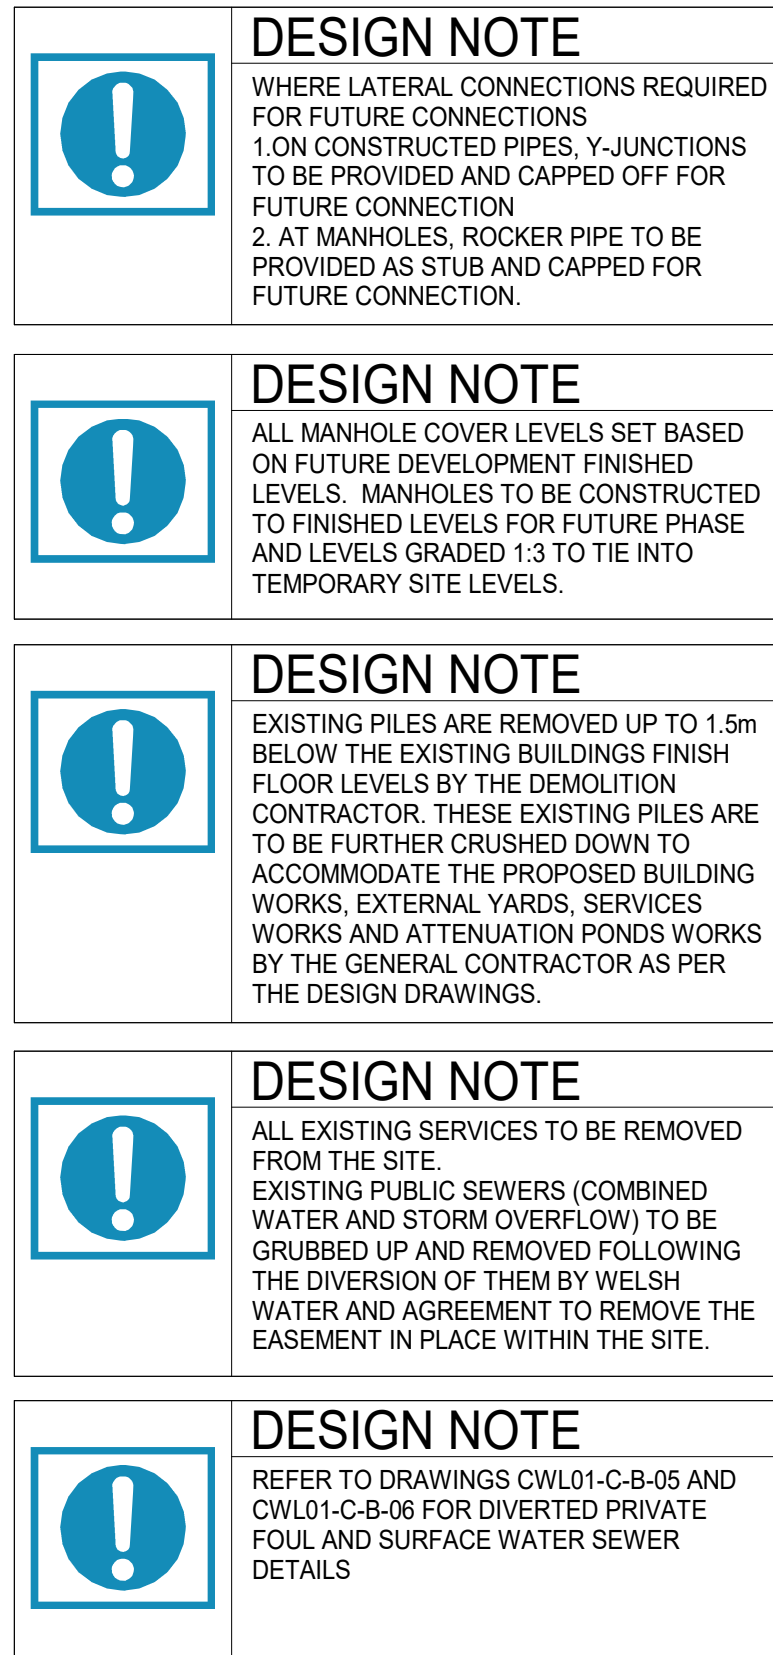

LEGEND

	SITE BOUNDARY
	EXISTING PUBLIC COMBINED SEWER
	EXISTING PUBLIC STORM OVERFLOW SEWER
	DIVERTED FOUL WATER SEWER
	DIVERTED STORM WATER SEWER
	PROPOSED COLO FOUL WATER SEWER
	PROPOSED FOUL WATER
	PROPOSED STORM WATER SEWER
	PROPOSED BLOWDOWN WATER METERING CHAMBER
	PROPOSED LINEAR DRAINAGE CHANNEL
	PROPOSED FOUL WATER RISING MAIN
	PROPOSED SURFACE WATER RISING MAIN
	INDICATIVE DRAINAGE LAYOUT FOR FUTURE DEVELOPMENT
	PROPOSED LAND DRAIN
	HEADWALL
	FOUL WATER STORAGE TANK
	OIL SEPARATOR
	FIRE WATER HOLDING TANK
	EXISTING EASEMENT

0 10 20 30 40 SCALE 1:1000

SCALE 1:1000

0 10 20 30 40

DIMENSIONS IN METRES

MICROSOFT CONFIDENTIAL

CWL01-C-D-01-0