



Rev:	Description:	By:	Date:
------	--------------	-----	-------

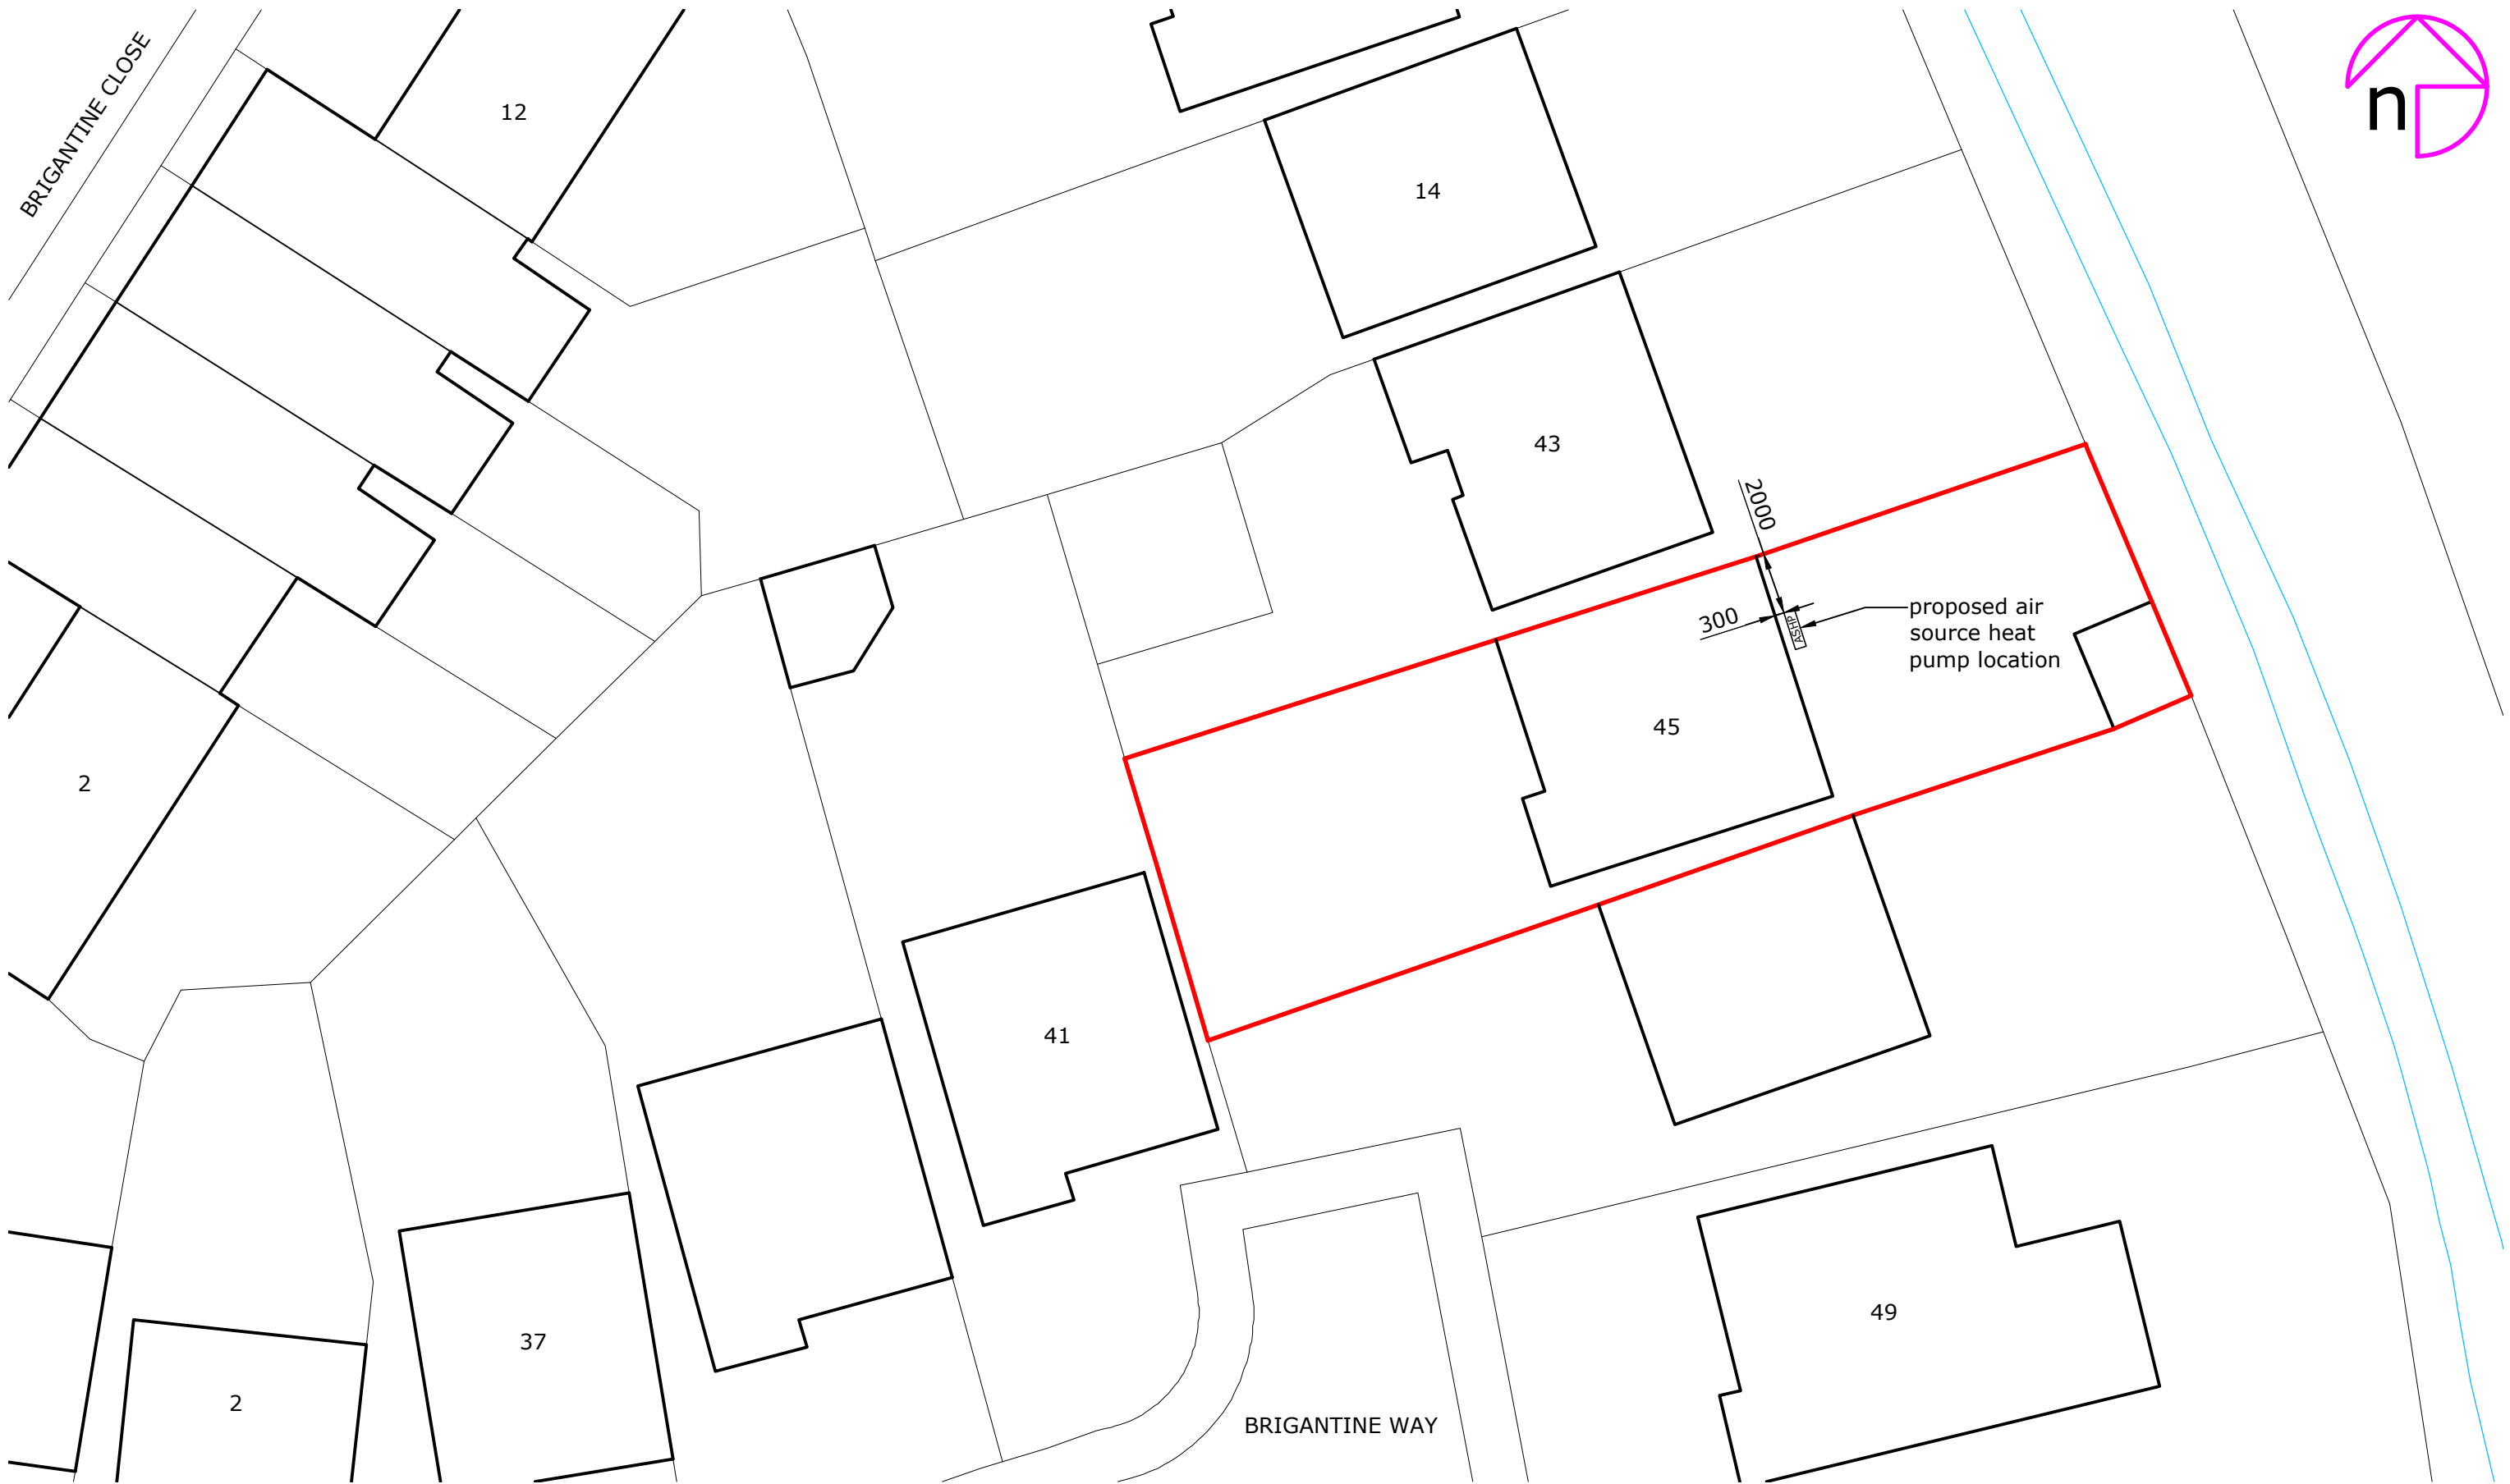

octopusenergy
services

Approved by:

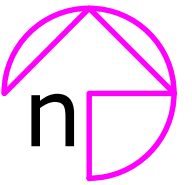

Client/Project: Jenny Brotheridge, 45, Brigantine Way, Newport, NP10 8EW	Project status: PLANNING (installation of air source heat pump) Drawing title: Site plan as proposed
---	---

Scale: 1:200	Paper Size: A3	Drawn: A Walton	Checked: ...
Project ID: J-AF56F4B9	Drawing No: 03	Revision:	Date: 14.02.2025