

This drawing is copyright:-

Figured dimensions must be taken in preference to scaled dimensions and ALL contractors and suppliers must check and verify al dimensions on site before preparing shop drawings, commencing work or pre-ordering of fixtures and fittings. It is deemed as part of good building practice that ALL contractors will have read an understood manufacturers instructions in relation to materials specified.




Atasayar Engineering Consulting
07594157070
enesatasayar@windowslive.com

31–34 Commercial Street,
Newport NP20 1RL

ALL contractors are to carry out the works indicated in accordance with the latest Building Regulations, British Standards, Codes of Practice, specifications and any legislation that may be in force @ the time of construction, together with latest robust standard details, NHBC specification of works and practices covered under both the Health and Safety at Work Act and current CDM regulations.

Work should only be undertaken from drawings referred to in the Local Authority approval documents

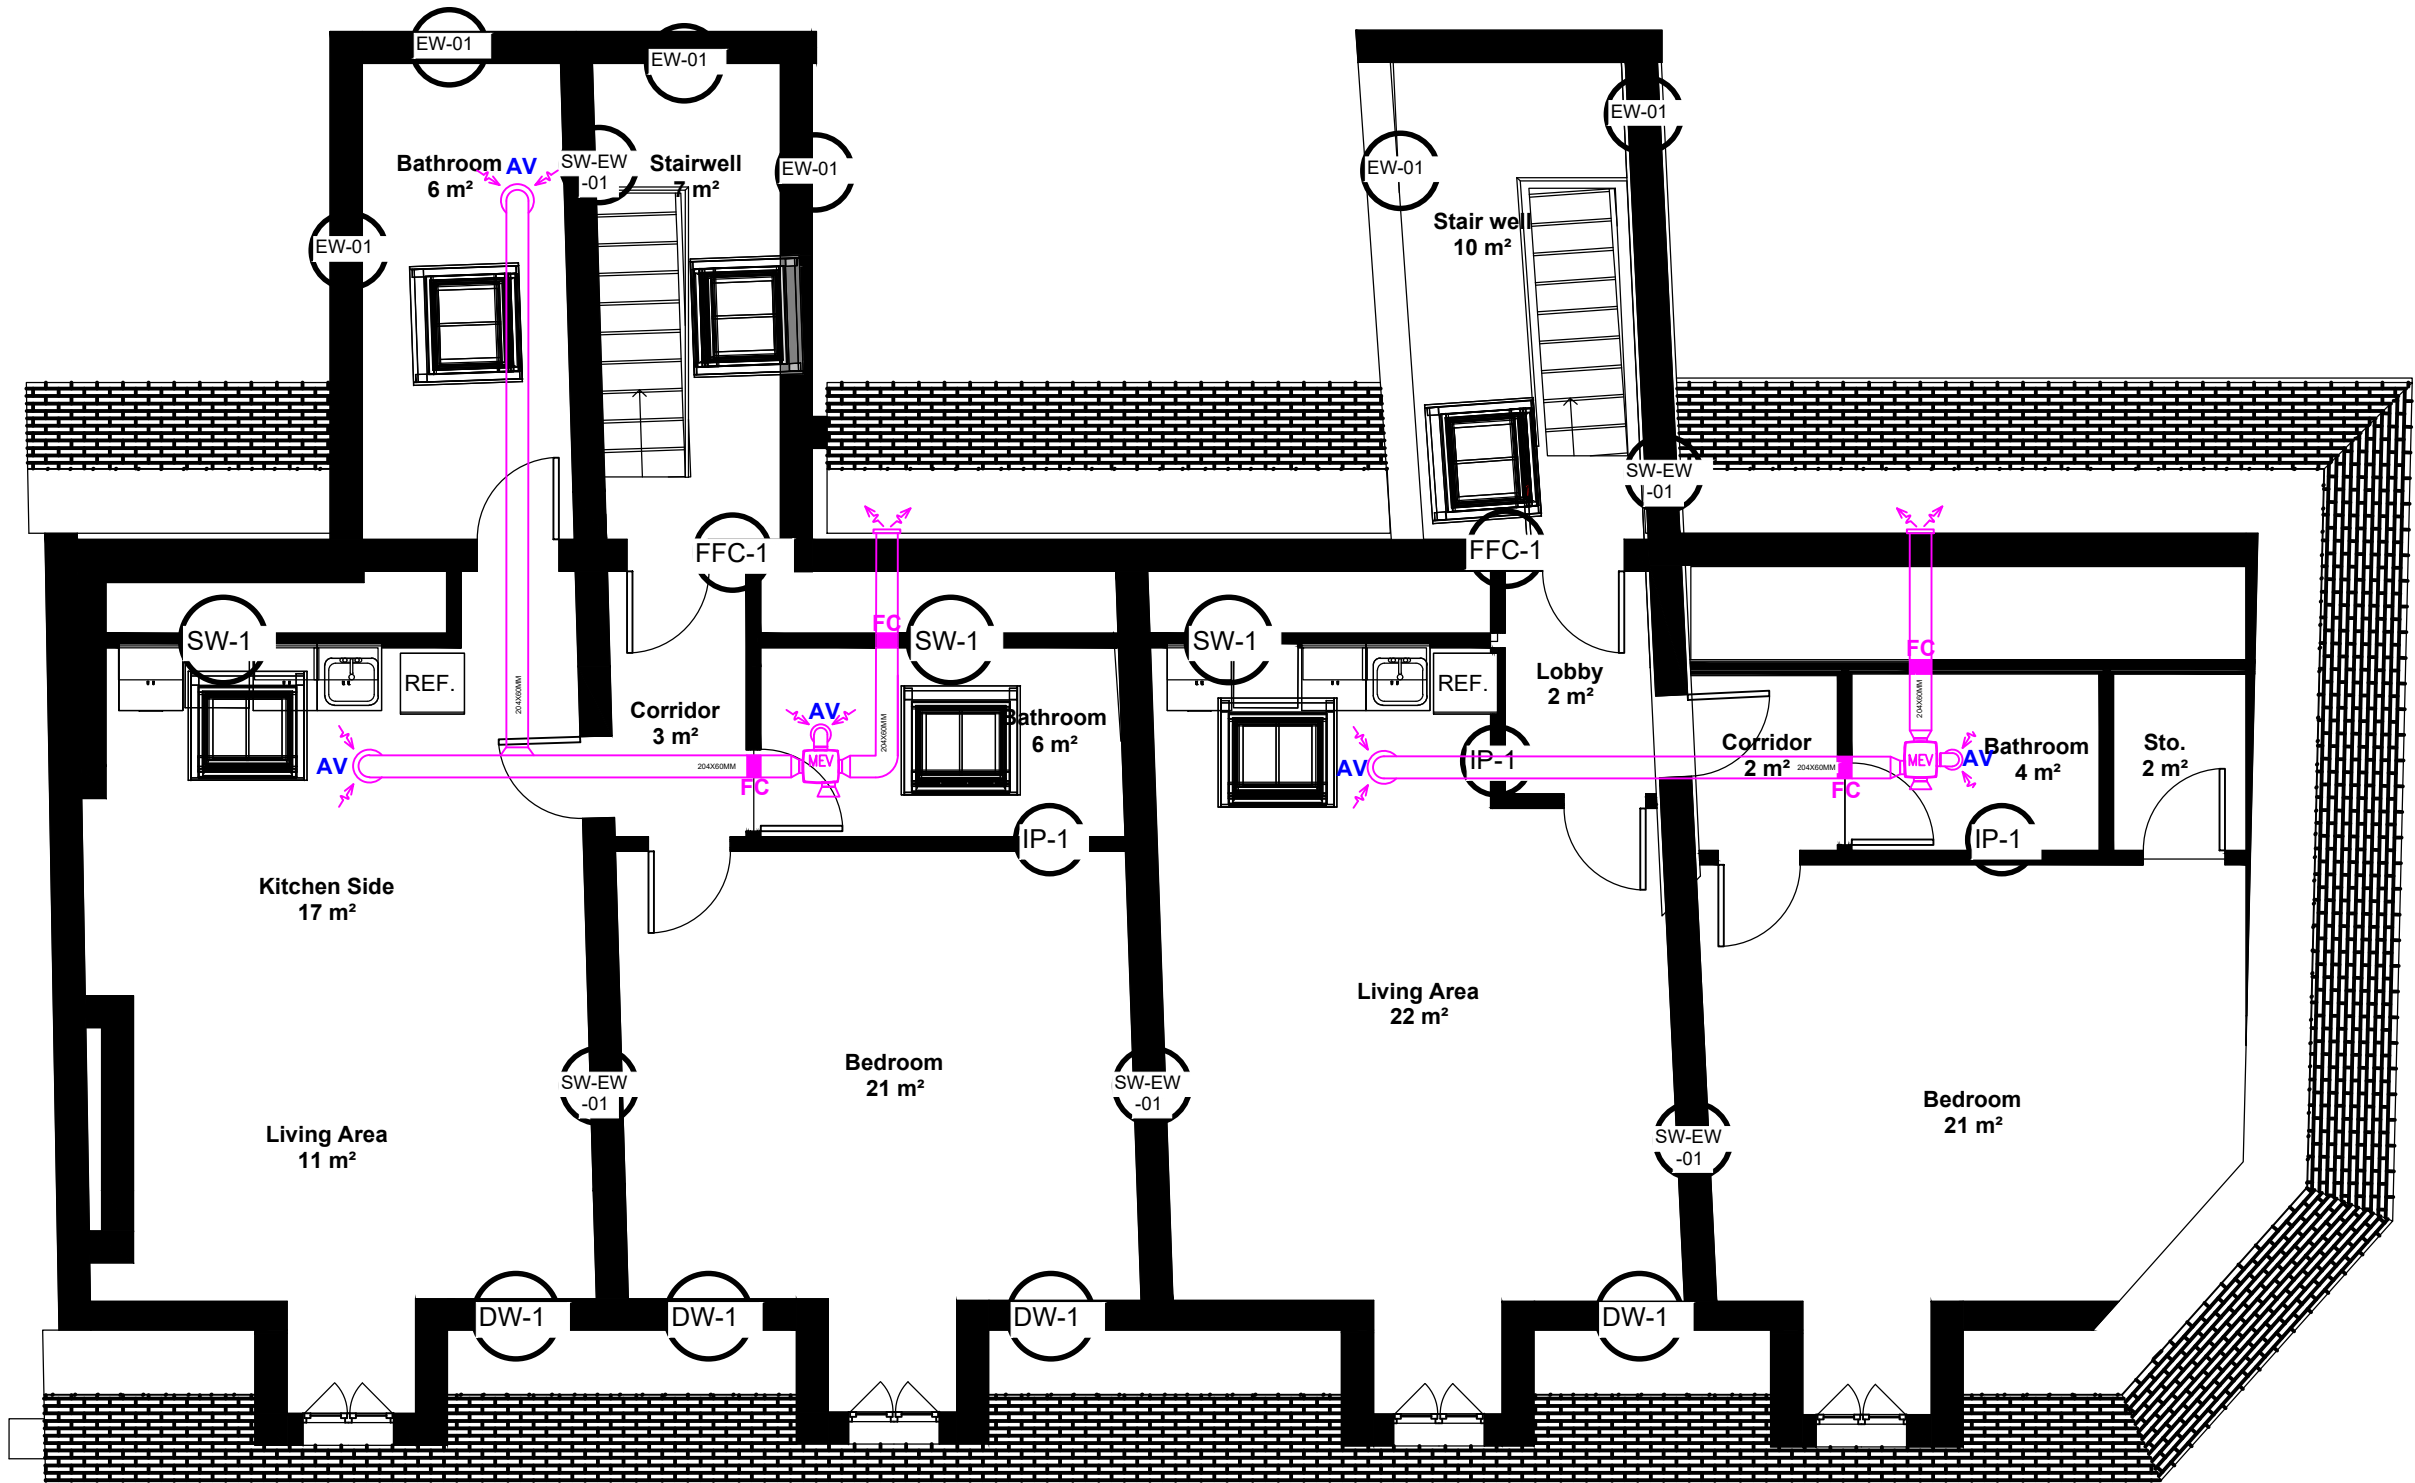

LEGEND

- EXISTING WALLS =EW-01
- SW-01-Seperating Walls between Flats
- IP-01- Internal Partition Walls
- FFC-01 -Seperating Walls Flat to Corridors
- SW-EX-01
- DW-01
- FC- Fire Collar / Intumescent
- AV- Air Valve 100mm/125mm
- MEV- Mechanical Extract Ventilation

Drawing No
ek-commercial01

Project Title
Fourth (Loft) Floor Plan-Vent Strategy

DATE:

June 2025

SCALE:

1 : 100

Scale 1:100

