


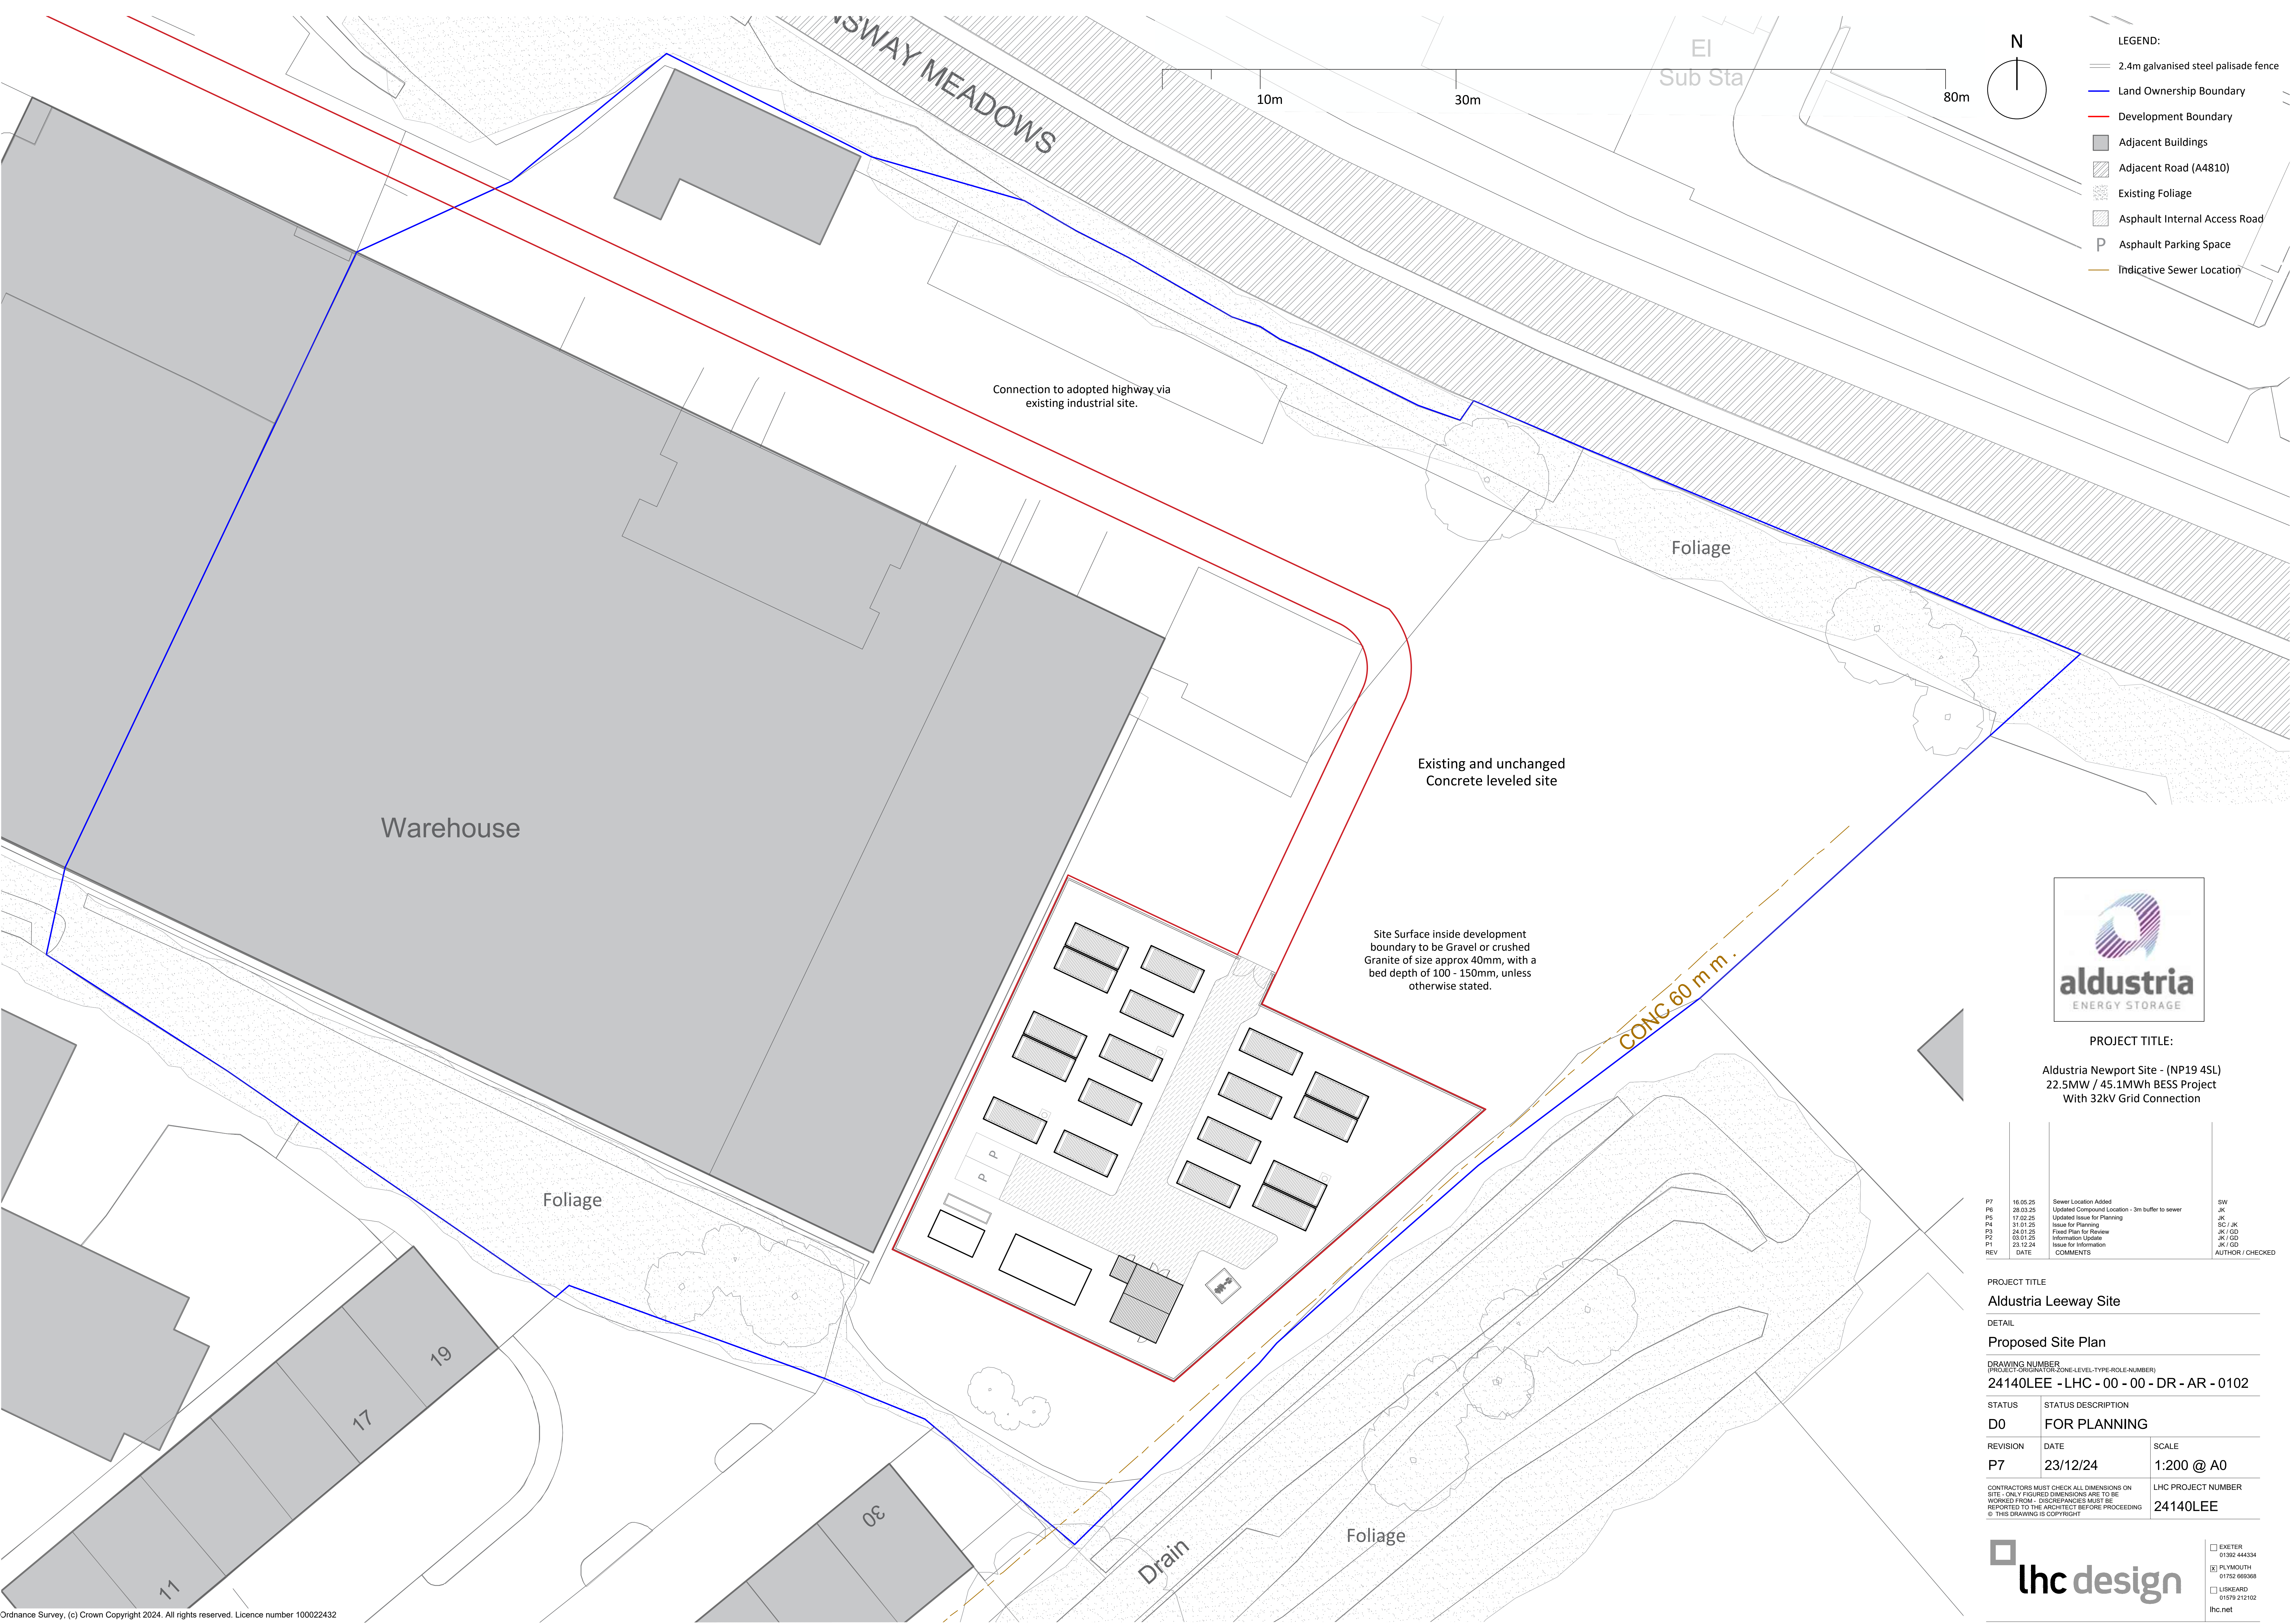

PROJECT TITLE:
Aldustria Newport Site - (NP19 4SL)
22.5MW / 45.1MWh BESS Project
With 32kV Grid Connection

P7	16.05.25	Sewer Location Added	SW
P6	08.03.25	Updated Compound Location - 3m buffer to sewer	JK
P5	17.02.25	Updated Issues for Planning	JK
P4	31.01.25	Issue for Planning	SG / JK
P3	24.01.25	Fixed Plan for Review	JK / GD
P2	03.01.25	Information Update	JK / GD
P1	23.12.24	Issue for Information	JK / GD
REV	DATE	COMMENTS	AUTHOR / CHECKED

PROJECT TITLE
Aldustria Leeway Site

DETAIL

Proposed Site Plan

DRAWING NUMBER
(PROJECT OVERLAY OR ZONE-LEVEL-TYPE-ROLE-NUMBER)
24140LEE - LHC - 00 - 00 - DR - AR - 0102

STATUS	STATUS DESCRIPTION	
D0	FOR PLANNING	
REVISION	DATE	SCALE
P7	23/12/24	1:200 @ A0

CONTRACTORS MUST CHECK ALL DIMENSIONS ON SITE - ONLY FIGURED DIMENSIONS ARE TO BE WORKED FROM - DISCREPANCIES MUST BE REPORTED TO THE ARCHITECT BEFORE PROCEEDING
© THIS DRAWING IS COPYRIGHT

LHC PROJECT NUMBER
24140LEE



☐ EXETER
01392 444334
☒ PLYMOUTH
01752 669368
☐ LISKEARD
01579 212102
lhc.net