

 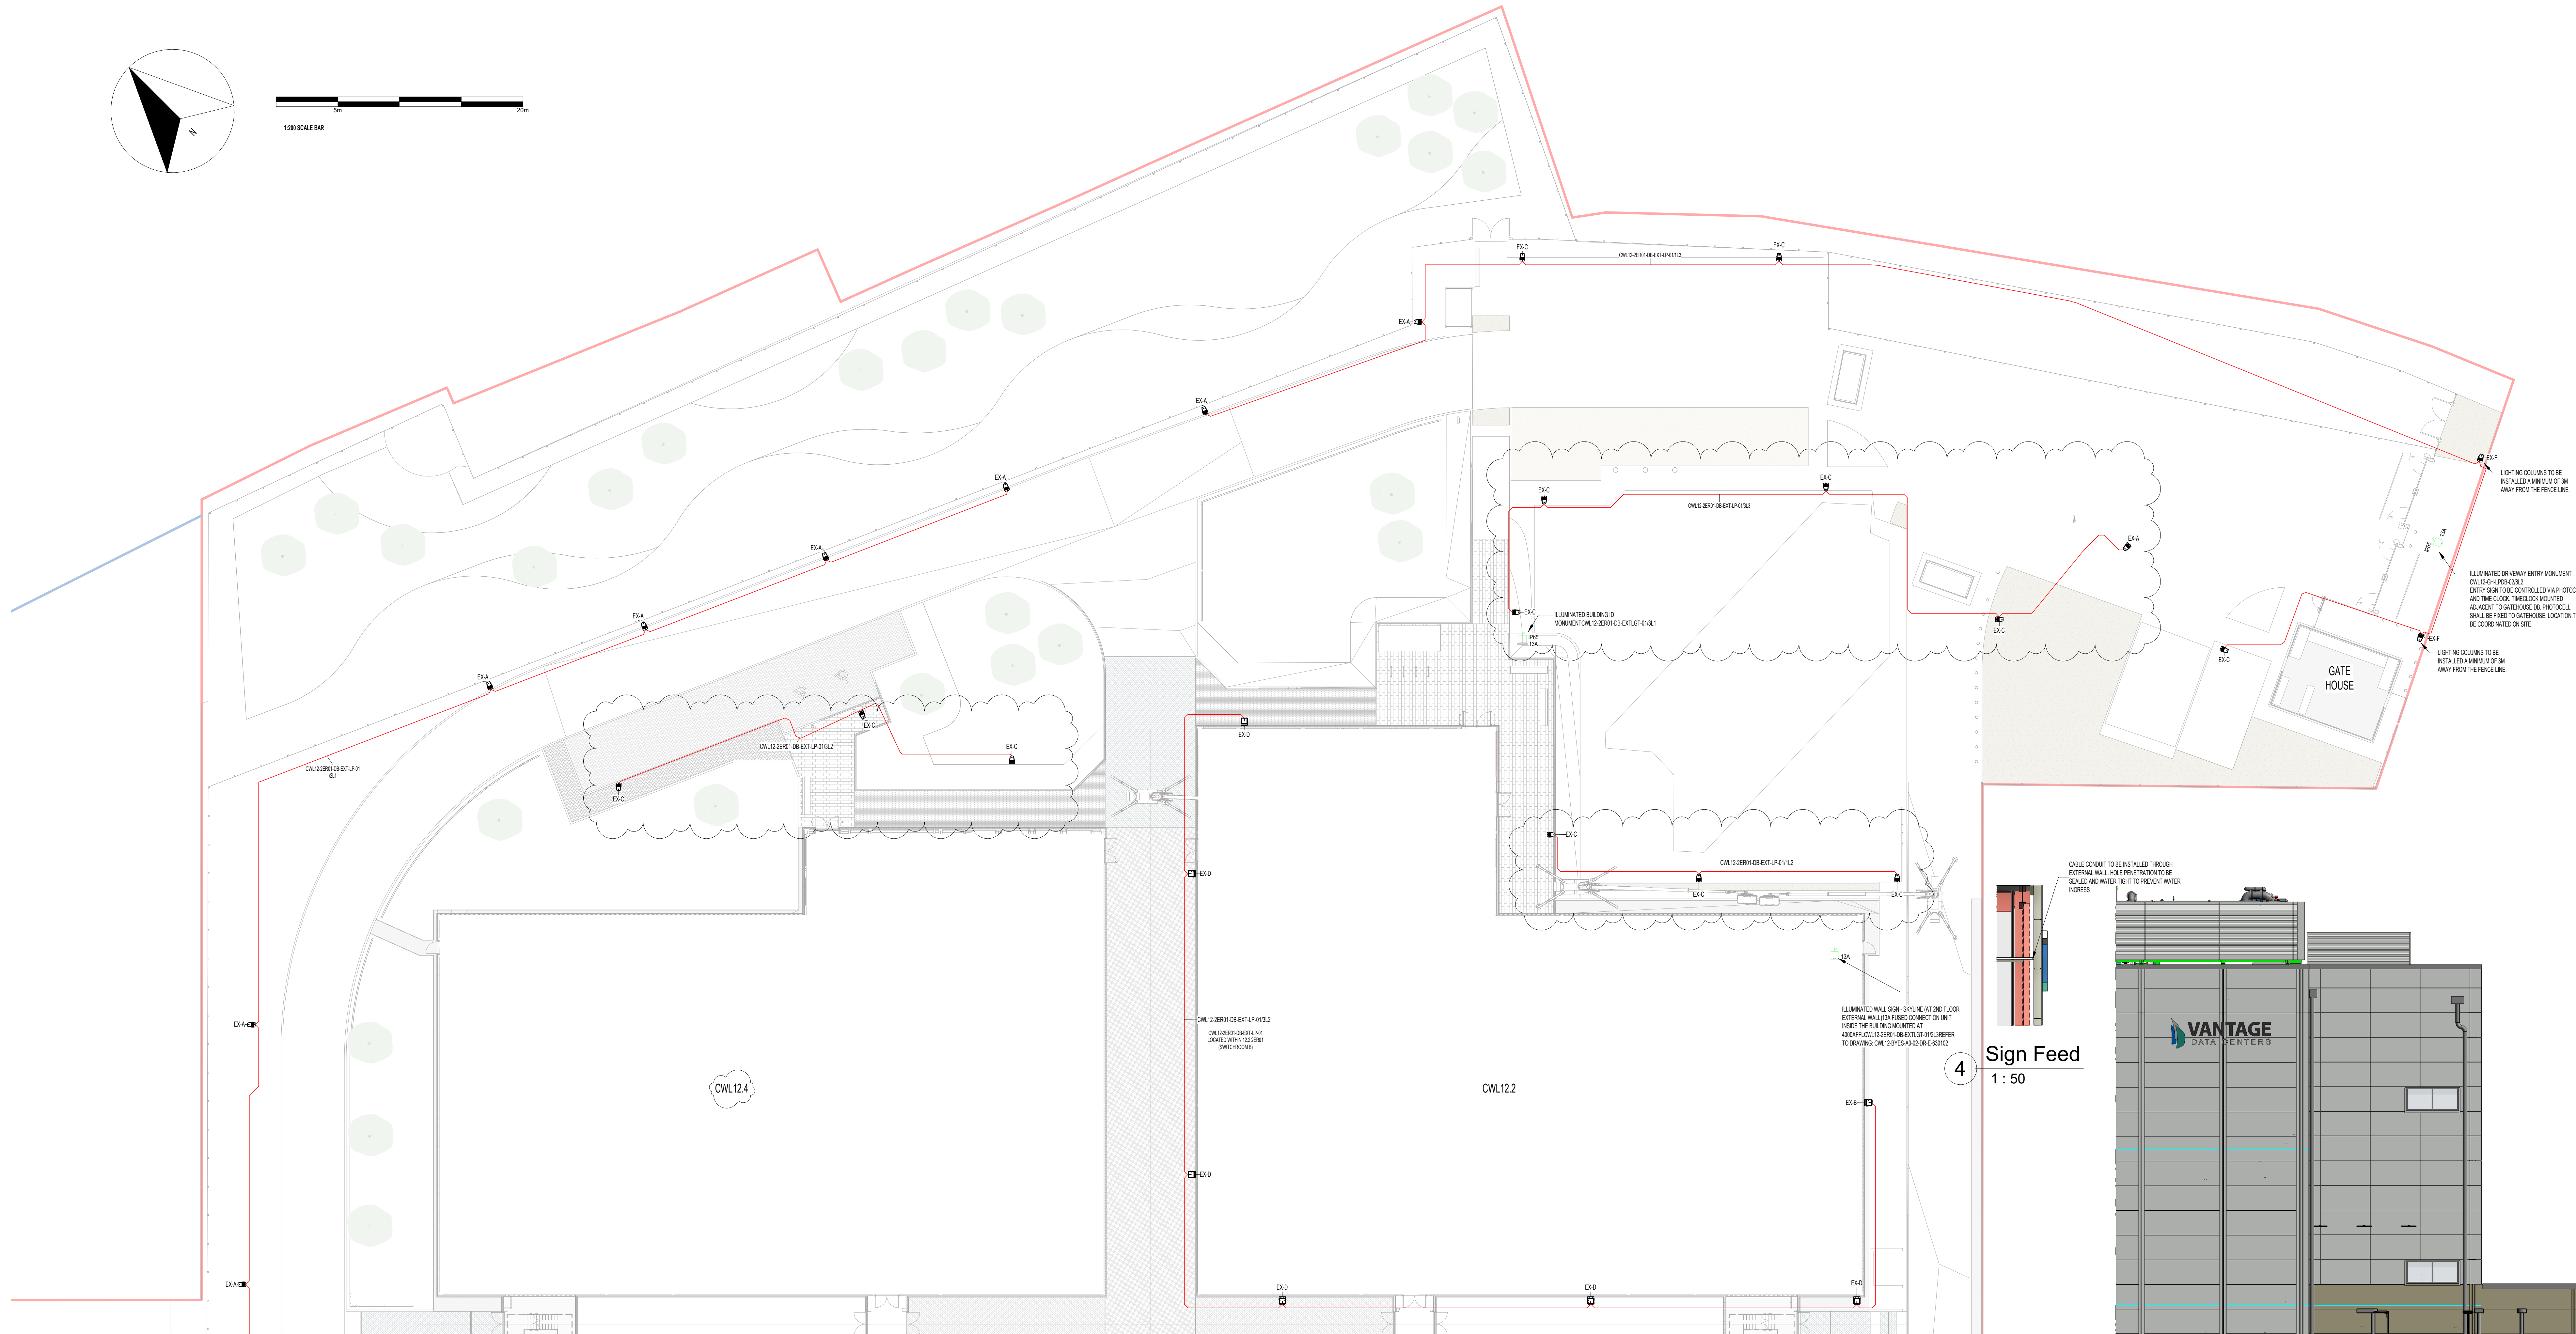


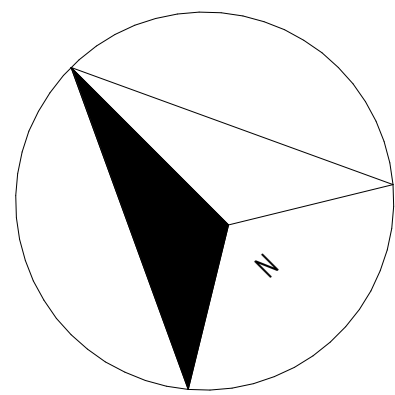

REFER TO SHEET CWL12-BYES-SW-SI-DR-E-630102 FOR CONTINUATION



Safety, Health and Environmental Information.

In Addition to the Hazards / Risks normally associated with the types of work indicated on this drawing, Note the Following.

Construction

1. Ensure all circuits have been isolated prior to any works as services are live at present.

Maintenance & Cleaning

Decommissioning & Demolition

1. Ensure all circuits have been isolated prior to any works as services are live at present.

NOTE: It is assumed that ALL works will be carried out by a contractor that is competent in the works identified and (where appropriate) the contractor works to an approved method statement.




EXTERNAL LIGHTING LEGEND

- EXA COLUMN HEIGHT - 10m
LANTERN - PHILIPS LUMISTREET BGP292
OPTIC - D351
LAMP - LED30 727
- EXB BUILDING MOUNTED FLOODLIGHT MOUNTED AT 10m MAIN BUILDING & 5m GENERATOR GANTRY
LANTERN - PHILIPS CLEARFLOOD G2 BVP655
OPTIC - A65 W8
- EXC COLUMN HEIGHT - 6m
LANTERN - PHILIPS LUMISTREET BGP292
OPTIC - D415 BL2 (BACK LOUVRE FULL CUT OFF)
LAMP - LED30 727
- EXD BUILDING MOUNTED FLOODLIGHT MOUNTED AT 4m
LANTERN - PHILIPS CLEARFLOOD G2 BVP655
OPTIC - A65 W8
LAMP - LED100 72
- EXE BUILDING MOUNTED FLOODLIGHT MOUNTED AT 10m
LANTERN - PHILIPS CLEARFLOOD G2 BVP655
OPTIC - A65 W8
LAMP - LED400 72
- EXF COLUMN HEIGHT - 10m
LANTERN - PHILIPS LUMISTREET BGP292
OPTIC - D415
LAMP - LED30 727
- EXG COLUMN HEIGHT - 10m
LANTERN - PHILIPS LUMISTREET BGP292
OPTIC - D415
LAMP - LED100 727


EXTERNAL LIGHTING NOTES

1. FOR CALCULATION DETAILS, REFER TO:
CWL12-BYES-SW-SI-DR-E-630101 INTERNAL & EXTERNAL LIGHTING CALCULATIONS.
2. FOR LUMINAIRE DETAILS, REFER TO:
CWL12-BYES-SW-SI-DR-E-630101 LUMINAIRE SCHEDULE.
3. ALL EXTERNAL LIGHTINGS TO BE CW OUTDOOR MULTISENSOR PROVIDING MOTION DETECTION AND DAYLIGHT CONTROL.
4. ILLUMINATED WALL SIGN AND ILLUMINATED BUILDING MONUMENT TO BE CONTROLLED WITH TIMECLOCK AND PHOTOCELL WITH BYPASS SWITCH.

SIGNIFY LIGHTING COLUMN LUMINAIRE MOUNTING CONNECTION DETAILS

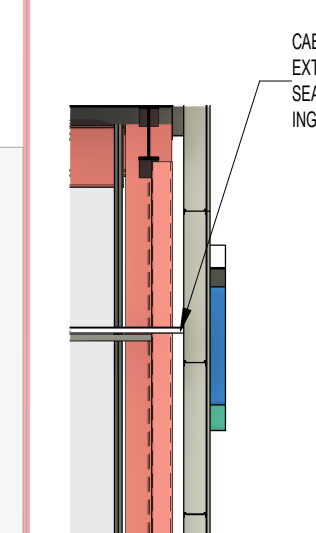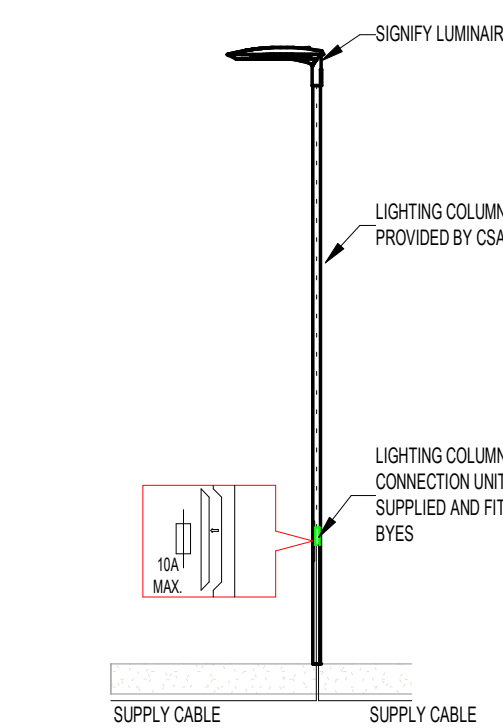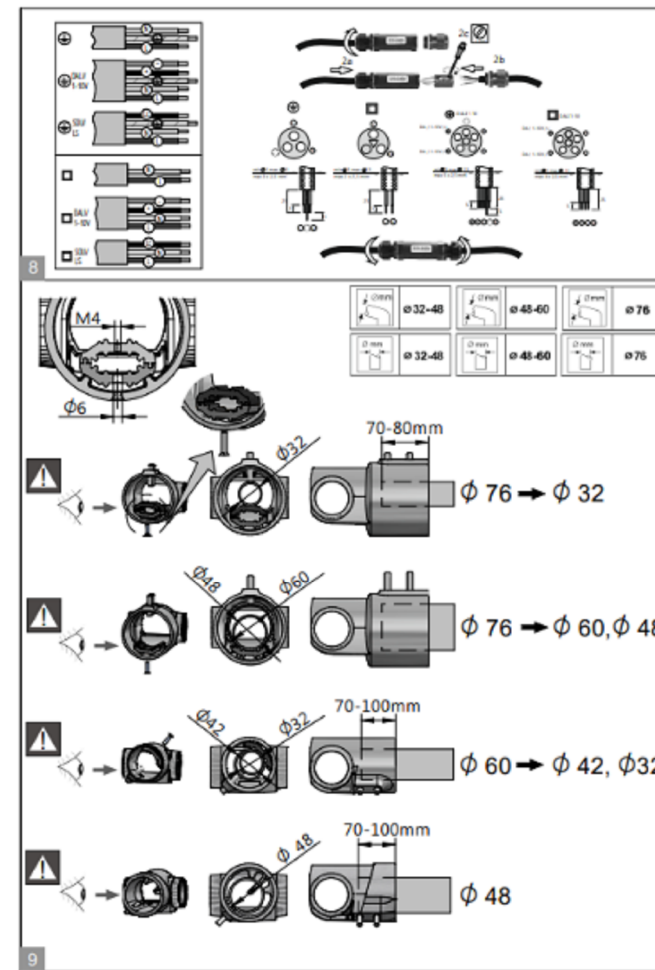

Sign Feed
1 : 50

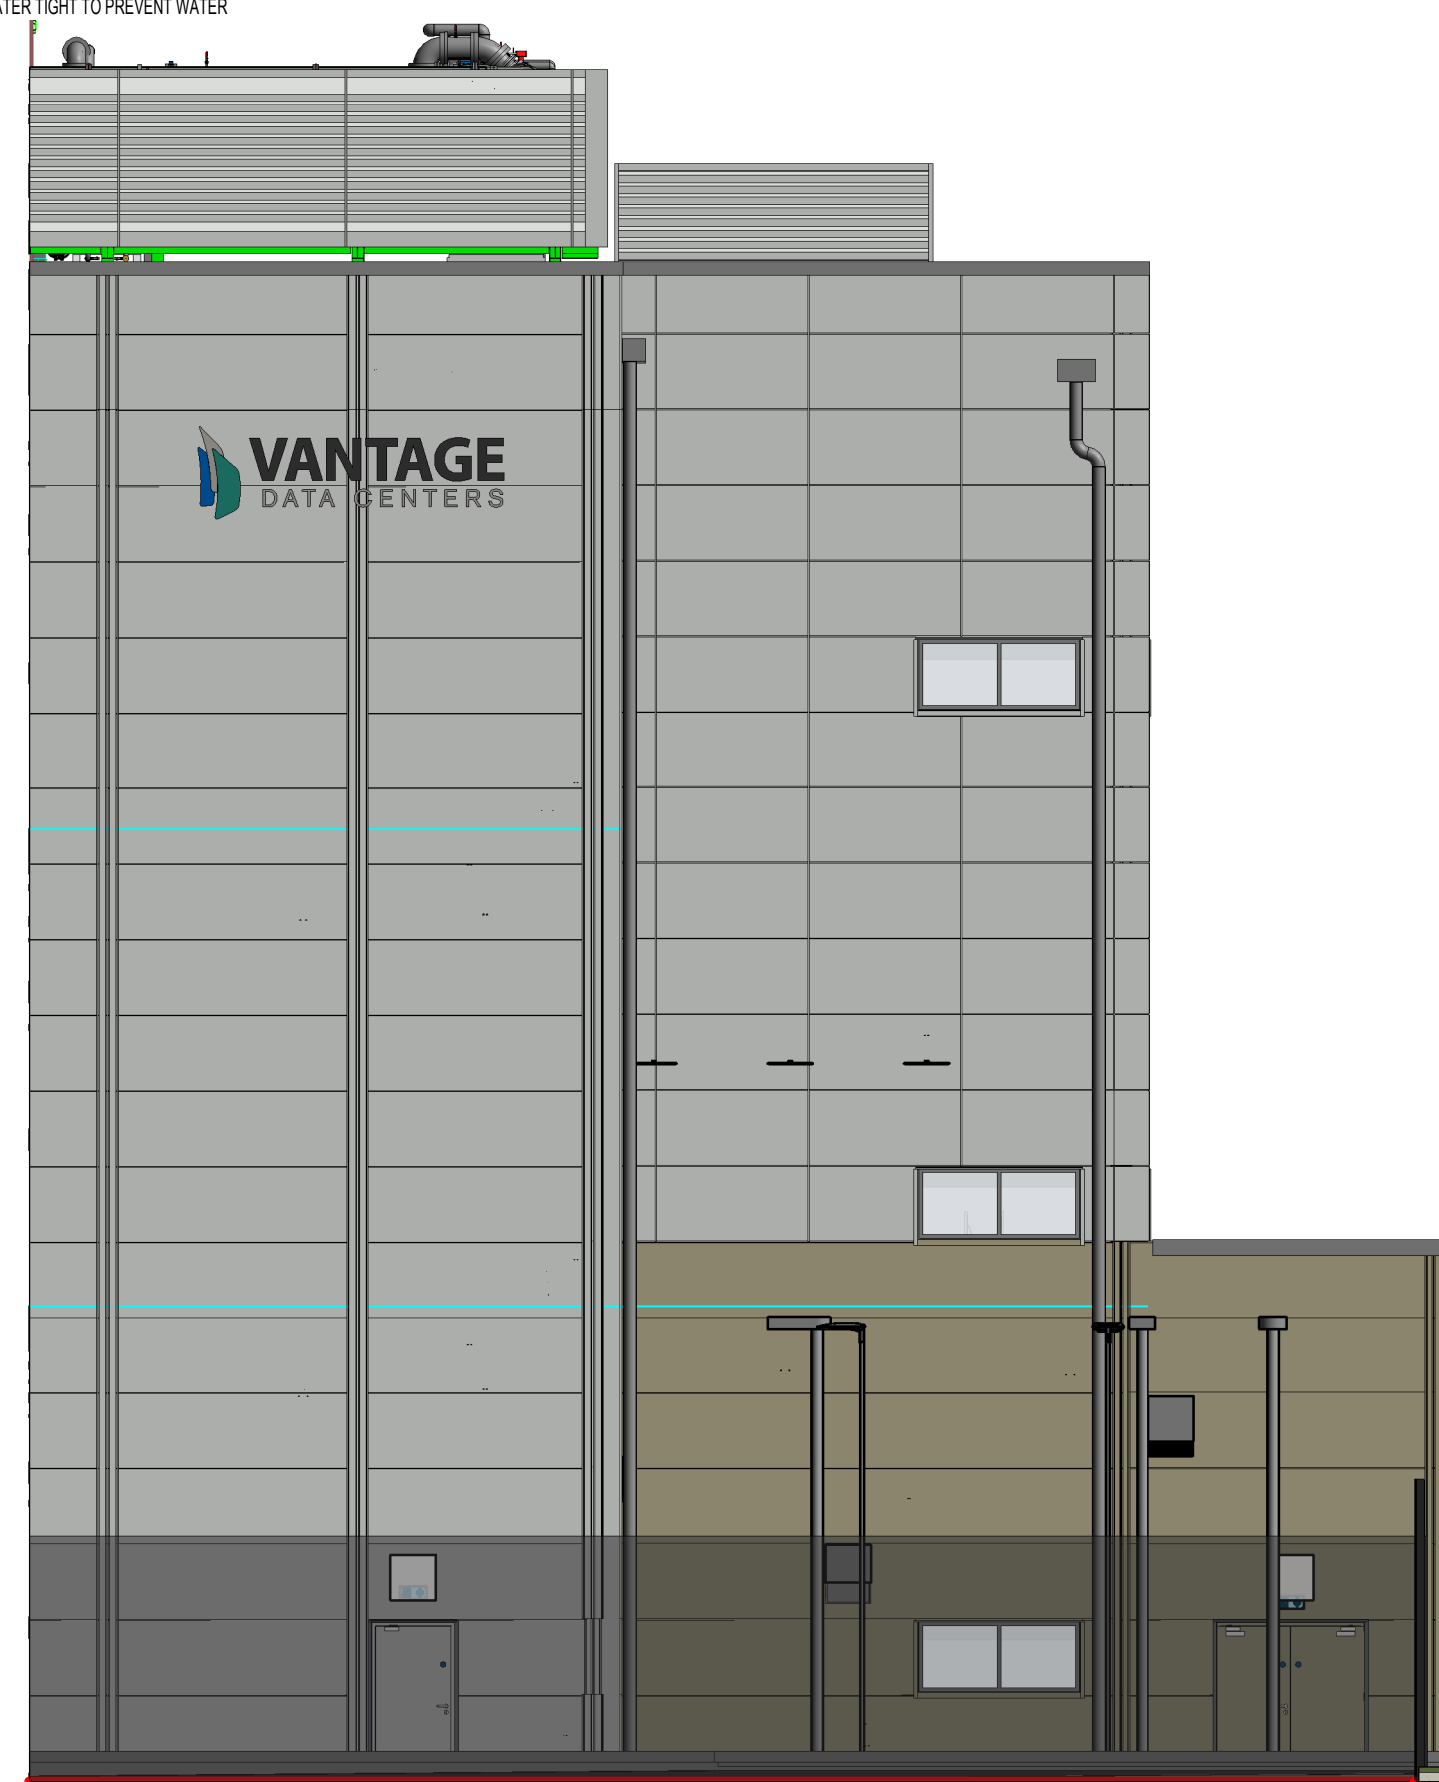

Sign Elevation
3

REV	DATE	BY	DESCRIPTION	CHK	APP
CSH	28/04/2026	SH	UPDATED WITH NEW REFERENCES AND PLANNING	DP	RM
CSH	28/04/2026	MAP	UPDATED AS PER BREXIT COMMENT	DP	PJ
CSH	28/04/2026	ZM	ALL LIGHTING REFERENCES & CIRCUIT REFERENCES AMENDED & CONNECTION DETAILS ADDED	DP	PJ
CSH	23/06/2025	ZM	CONSTRUCTION ISSUE	RM	PJ

NO CHANGES TO MAKE AND CONFIRMING THE IS THE PROPERTY OF BOURGES SUE & NED NOT BE COPIED OR LOAN WITHOUT THE CONSENT OF BOURGES SUE & NED MUST BE RETURNED WITHIN THREE MONTHS OF COMPLETION OF WORKS.



One Disbury Point, 2 The Avenue
Manchester, M20 2EY, UK
Tel: +44 (0)161 249 1000

Excel House, Europoint Office Park, 1 Renshaw Place Holytown,
Motherwell, ML1 4JF, UK
Tel: +44 (0)1698 655 500

Beckett House, 1 Lambeth Palace Road,
London, SE1 7EU, UK
Tel: +44 (0)207 401 0020

Client

Vantage

Project

CWL12

Drawing No.

Electrical Services
Lighting Layout
CWL12 External Sheet 01

Construction

Drawn	Designed	Size
ZM	KW	23/06/2025
Checked	Approved	Scale
RM	PJ	1:200
Rev	Project No.	Drawing No.
770004	CWL12-BYES-SW-SI-DR-E-630101	004
Project	Manager	Drawn

DESIGN RESPONSIBILITY FOR THIS DRAWING
REMAINS WITH HYDROCK, IN ACCORDANCE
WITH THEIR APPOINTMENT