

In Addition to the Hazards / Risks normally associated with the types of work indicated on this drawing, Note the Following.

Construction
1. Ensure all circuits have been isolated prior to any works as services are live at present.

Maintenance & Cleaning

Decommissioning & Demolition

1. Ensure all circuits have been isolated prior to any works as services are live at present.

NOTE: It is assumed that ALL works will be carried out by a contractor that is competent in the works identified and (where appropriate) the contractor works to an approved method statement.



EXTERNAL LIGHTING LEGEND

- EX-A COLUMN HEIGHT - 10m
LANTERN - PHILIPS LUMSTREET BGP292
OPTIC - D051
LAMP - LED80 727
- EX-B BUILDING MOUNTED FLOODLIGHT MOUNTED AT 10m MAIN
BUILDING & 5m GENERATOR GENTRY
LANTERN - PHILIPS CLEARFLOOD G2 BYP655
OPTIC - AG5-W8
LAMP - LED80 727
- EX-C COLUMN HEIGHT - 6m
LANTERN - PHILIPS LUMSTREET BGP292
OPTIC - DM10 BL2 (BACK LOUVER FULL CUT OFF)
LAMP - LED80 727
- EX-D BUILDING MOUNTED FLOODLIGHT MOUNTED AT 4m
LANTERN - PHILIPS CLEARFLOOD G2 BYP655
OPTIC - AG5-W8
LAMP - LED100 72
- EX-E BUILDING MOUNTED FLOODLIGHT MOUNTED AT 10m
LANTERN - PHILIPS CLEARFLOOD G2 BYP655
OPTIC - AG5-W8
LAMP - LED400 72
- EX-F COLUMN HEIGHT - 10m
LANTERN - PHILIPS LUMSTREET BGP294
OPTIC - DM10
LAMP - LED80 727
- EX-G COLUMN HEIGHT - 10m
LANTERN - PHILIPS LUMSTREET BGP292
OPTIC - DM10
LAMP - LED120 727

EXTERNAL LIGHTING NOTES

- FOR CALCULATION DETAILS. REFER TO:
CWL12-BYES-SW-ZZ-CA-E-630101 INTERNAL & EXTERNAL LIGHTING CALCULATIONS.
- FOR LUMINAIRE DETAILS. REFER TO:
CWL12-BYES-SW-ZZ-SH-E-63001 LUMINAIRE SCHEDULE.
- ALL EXTERNAL LIGHTINGS TO BE CW OUTDOOR MULTISENSOR PROVIDING MOTION DETECTION AND DAYLIGHT CONTROLS
- ILLUMINATED WALL SIGN AND ILLUMINATED BUILDING ID MONUMENT TO BE CONTROLLED WITH TIMESLOCK PHOTOCELL WITH BYPASS SWITCH

SIGNIFY LIGHTING COLUMN LUMINAIRE MOUNTING CONNECTION DETAILS

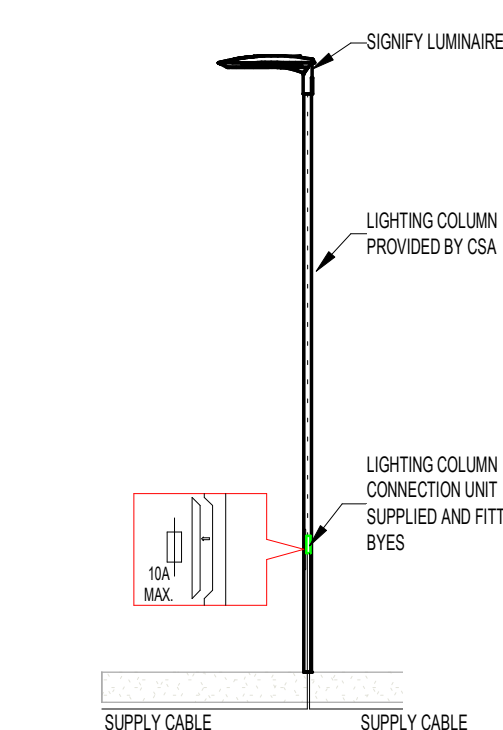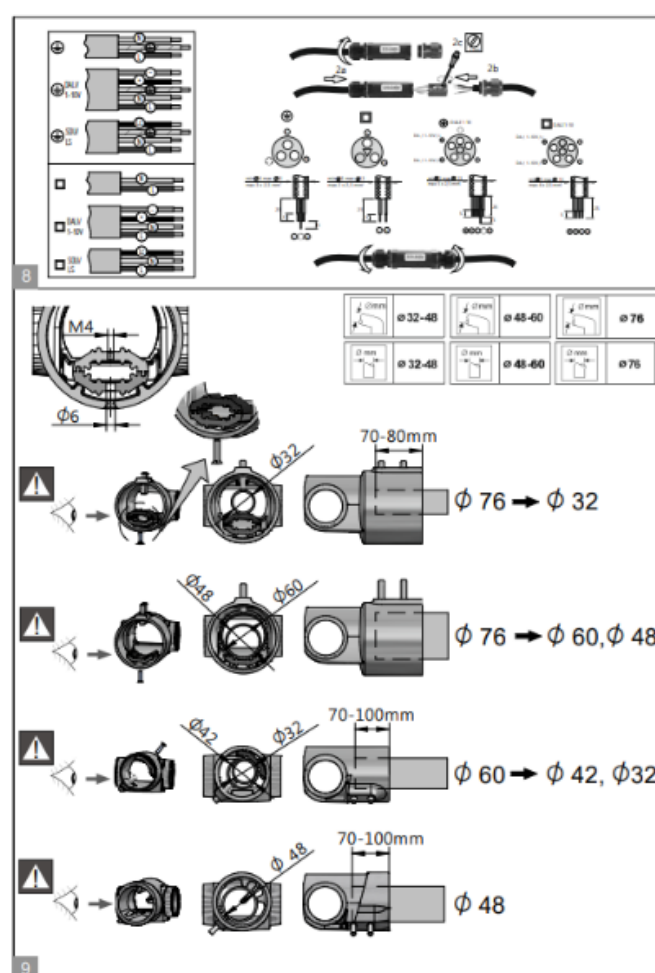

REV	DATE	BY	DESCRIPTION	CHK	APP
CSH	28/04/20	SH	UPDATED WITH NEW REFERENCES AND PLANNING	DP	RM
CSH	28/04/20	SH	UPDATED IN ACCORDANCE WITH BREXIT COMMENT	DP	PJ
CSH	28/04/20	SH	ALL LIGHTING REFERENCES & CIRCUIT REFERENCES AMENDED & CONNECTION DETAILS ADDED	DP	PJ
CSH	23/06/20	SH	CONSTRUCTION ISSUE	RM	PJ

NO CHANGES TO MAKE AND NO CHANGES ARE TO BE MADE TO THE DRAWING OR BIDDING L&L. IF ANY CHANGES ARE REQUIRED, THEY MUST BE APPROVED BY THE CLIENT.

BOUYOUES
ELECTRICAL SERVICES

One Didsbury Point, 2 The Avenue
Manchester, M20 2EY, UK
Tel: +44 (0)161 249 1000

Excel House, Europoint Office Park, 1 Renshaw Place Holytown,
Motherwell, ML1 4UF, UK
Tel: +44 (0)1698 885 500

Beckett House, 1 Lambeth Palace Road,
London, SE1 7EU, UK
Tel: +44 (0)207 401 0020

Client:

Vantage

Project:

CWL12



Drawing No:

Electrical Services
Lighting Layout
CWL12 External Sheet 02

Construction

Drawn	Designed	Scale	Revision
RM	KW	23/06/2020	
Checked	Approved	Scale	
RM	PJ	1:200	
Drawn Project No.	Drawing No.	Project	Revision
770004	CWL12-BYES-SW-SI-DR-E-630102		C04

DESIGN RESPONSIBILITY FOR THIS DRAWING
REMAINS WITH HYDROCK, IN ACCORDANCE
WITH ITS APPOINTMENT

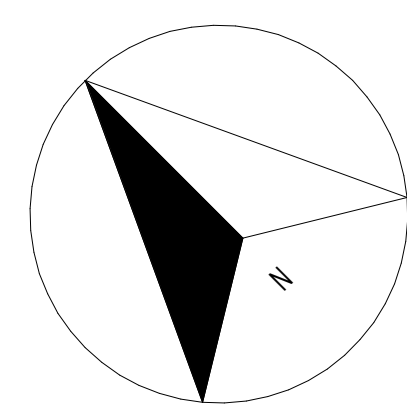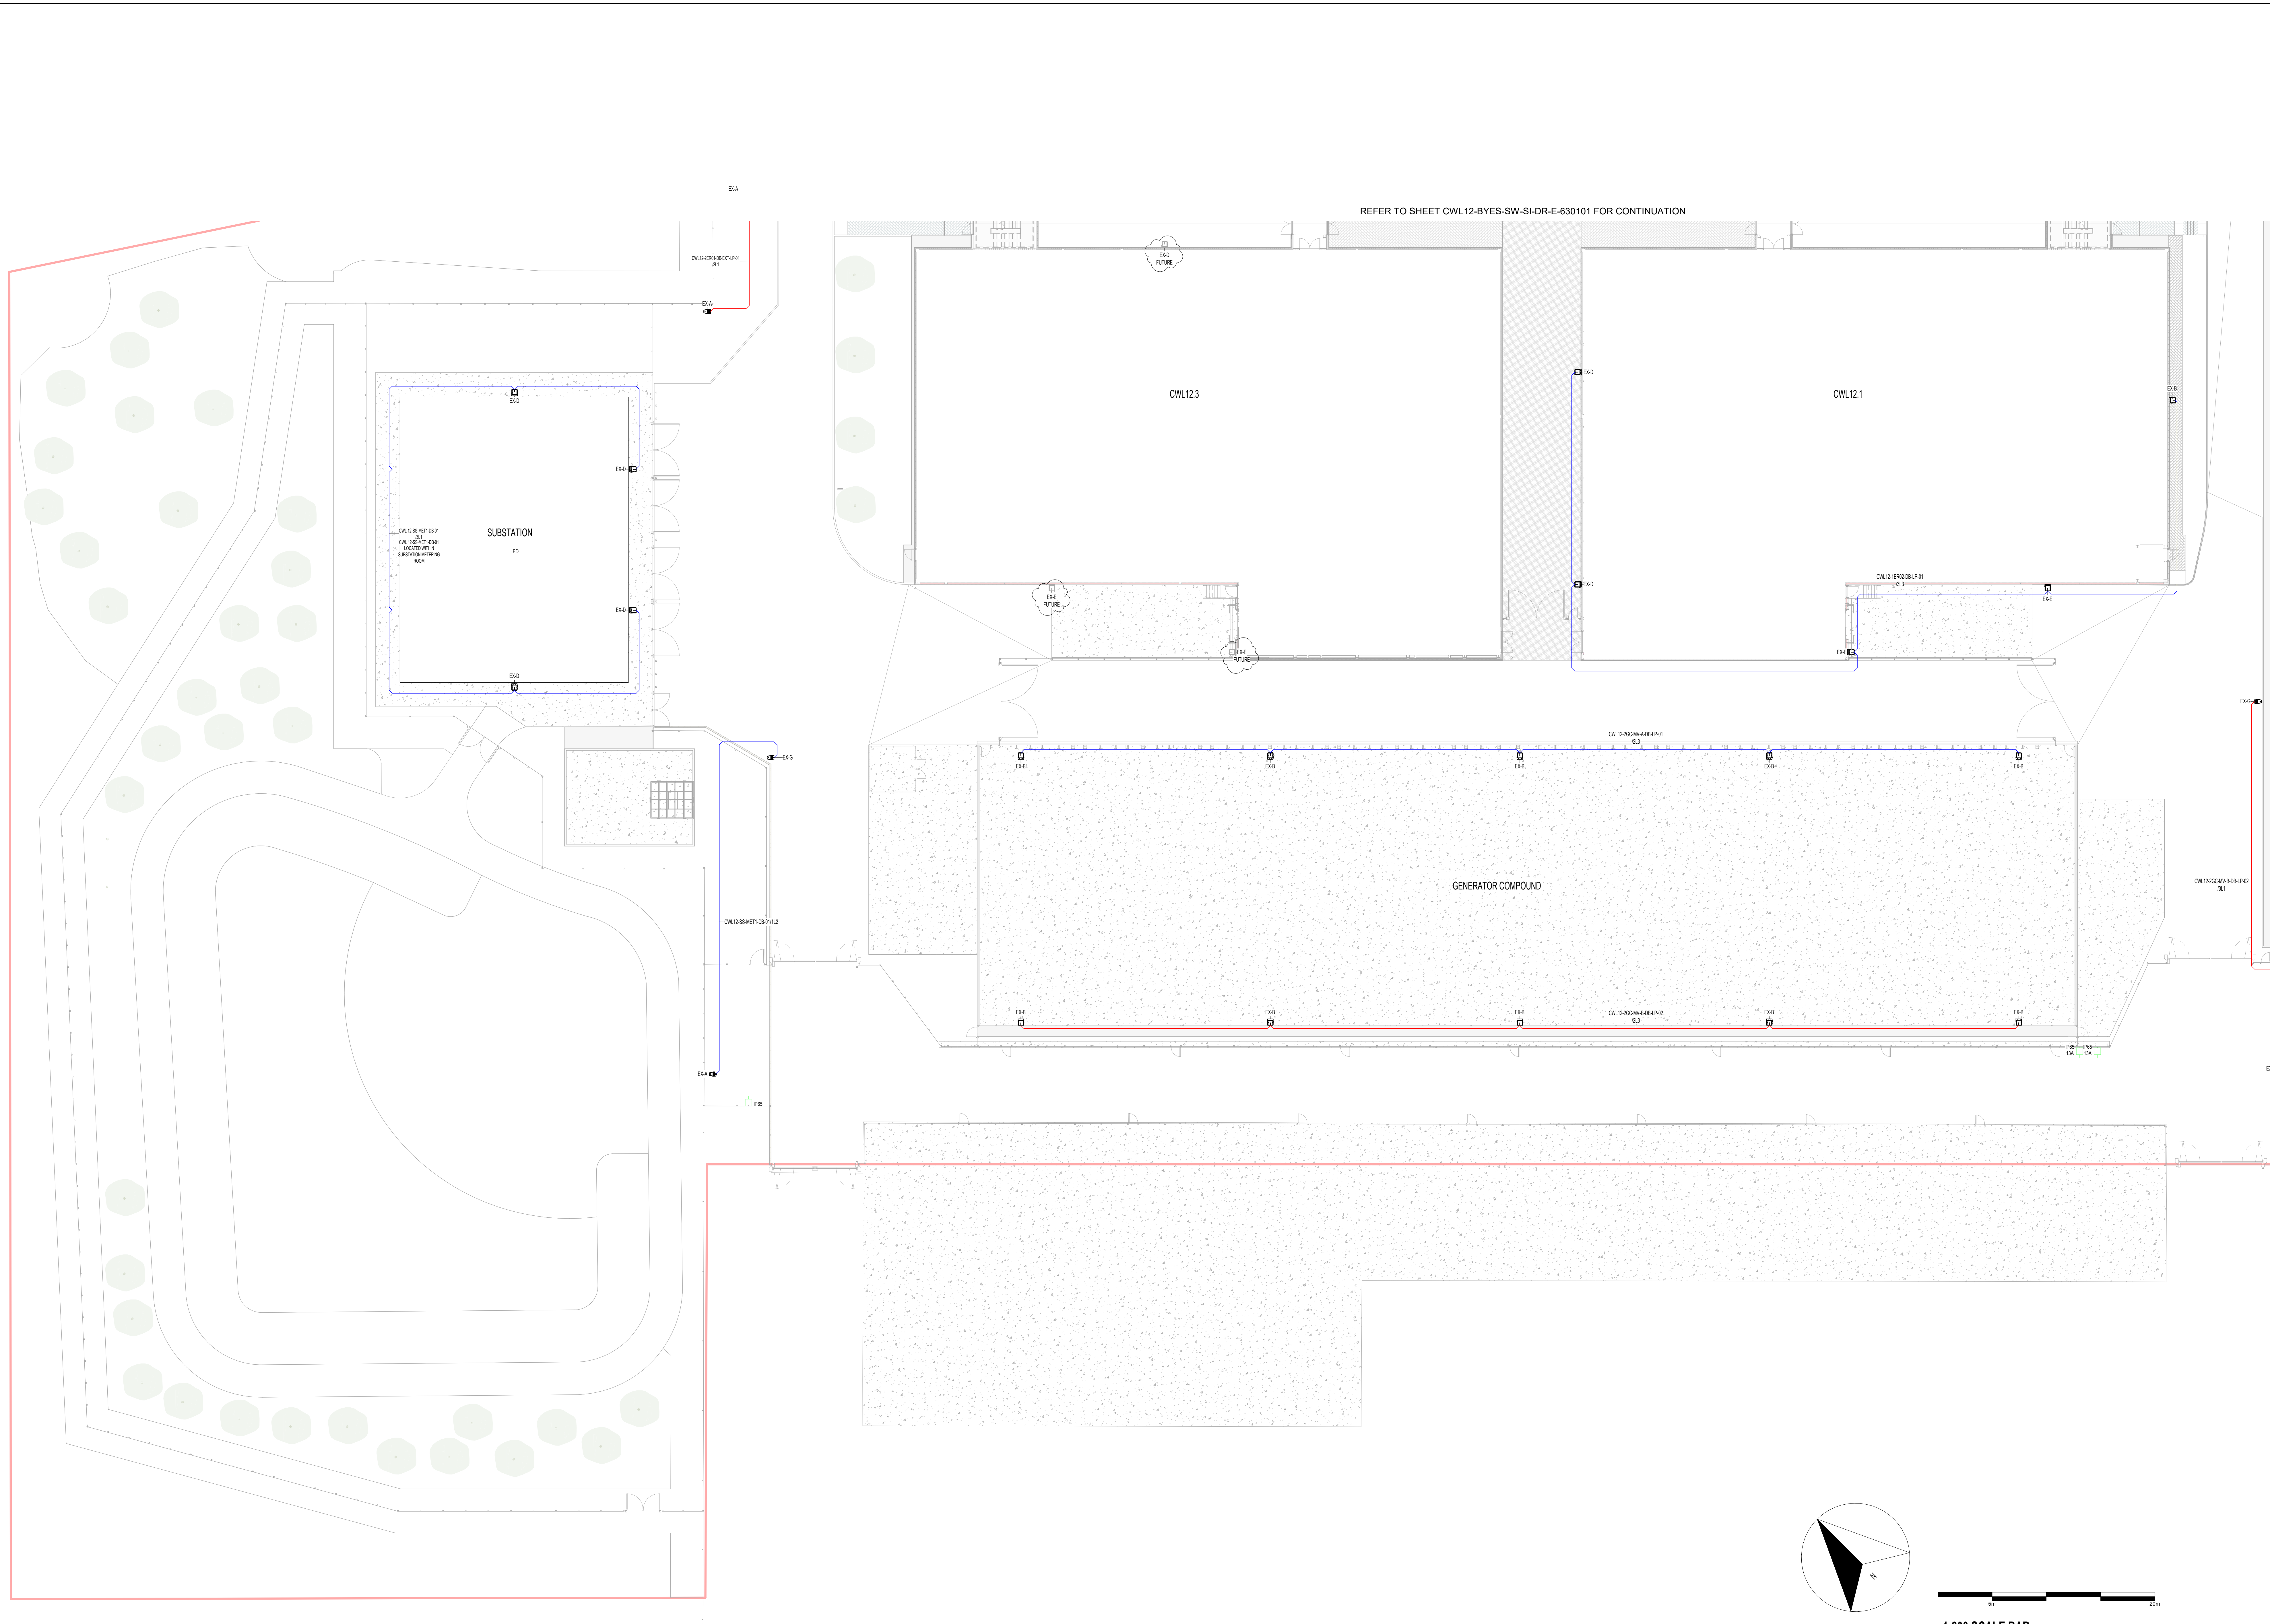

1:200 SCALE BAR