


Rev:	Description:	By:	Date:
------	--------------	-----	-------

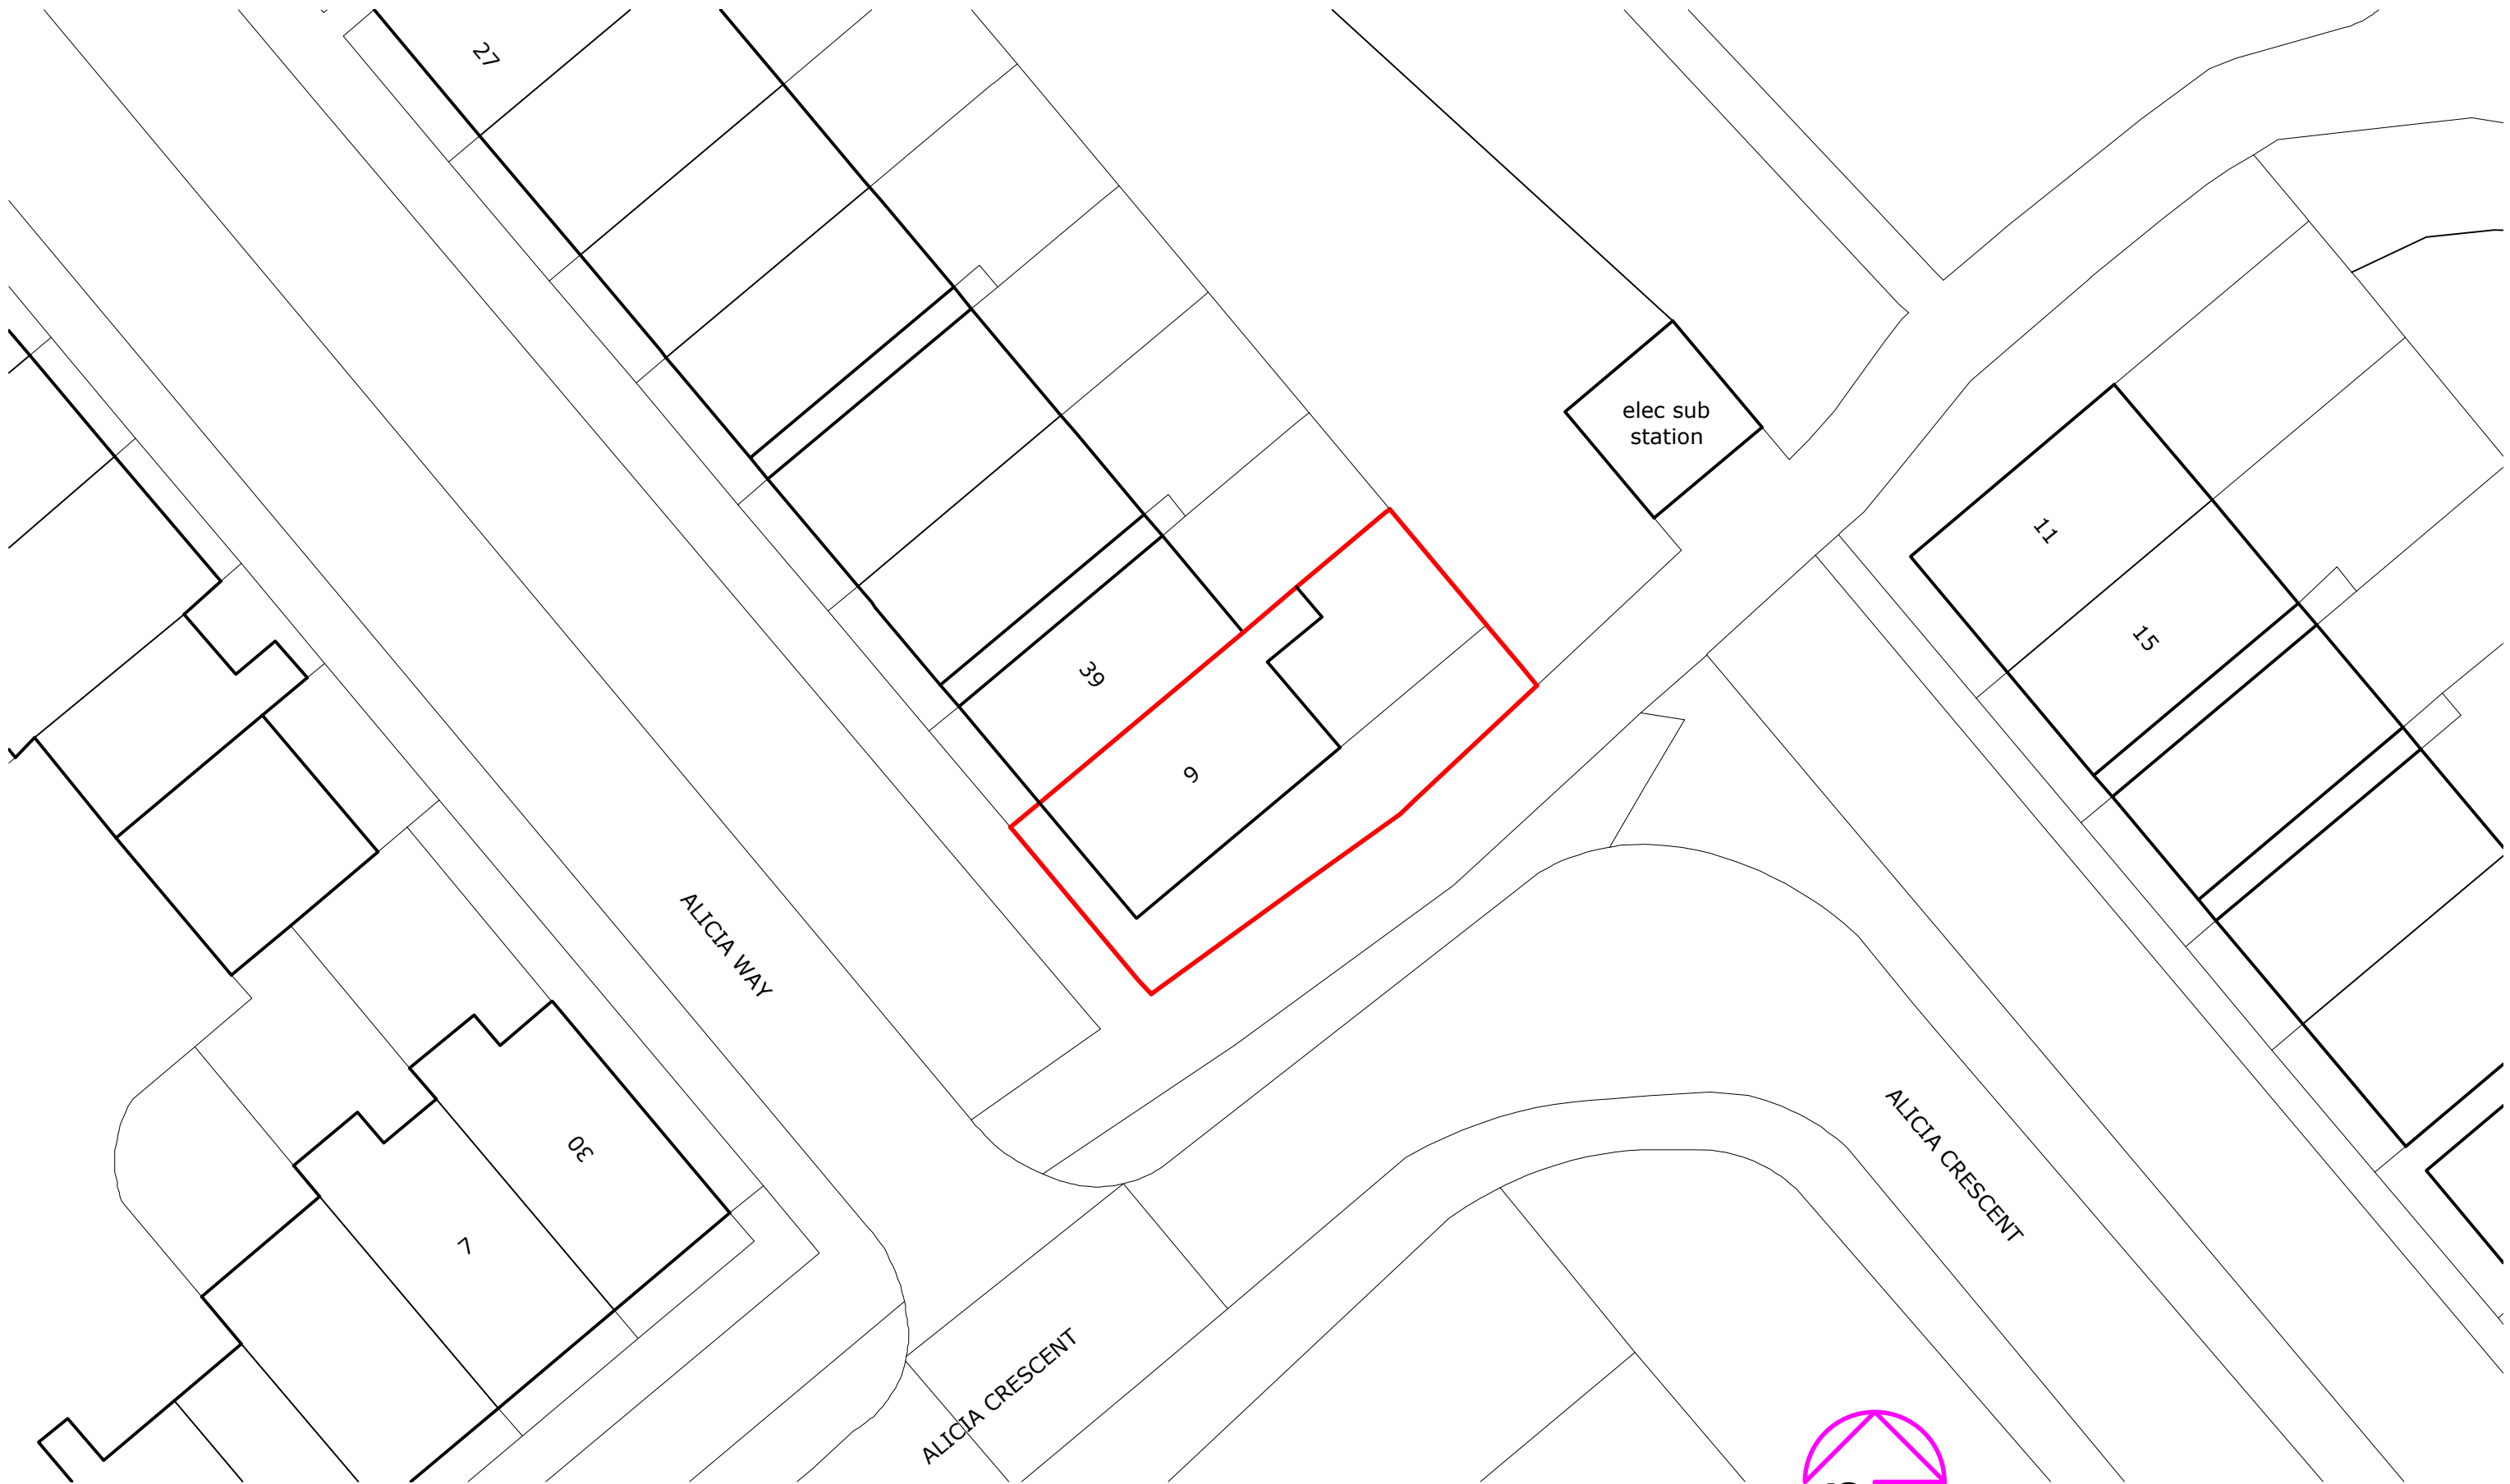

octopusenergy
services

Approved by:



Client/Project: Brandon Villiers, 9 Alicia Crescent, Newport, NP20 2FJ	Project status: PLANNING (installation of air source heat pump) Drawing title: Site plan as existing
---	--

Scale: 1:200	Paper Size: A3	Drawn: A Walton	Checked: ...
Project ID: J-B192A1F9	Drawing No: 01	Revision:	Date: 19.02.2025