
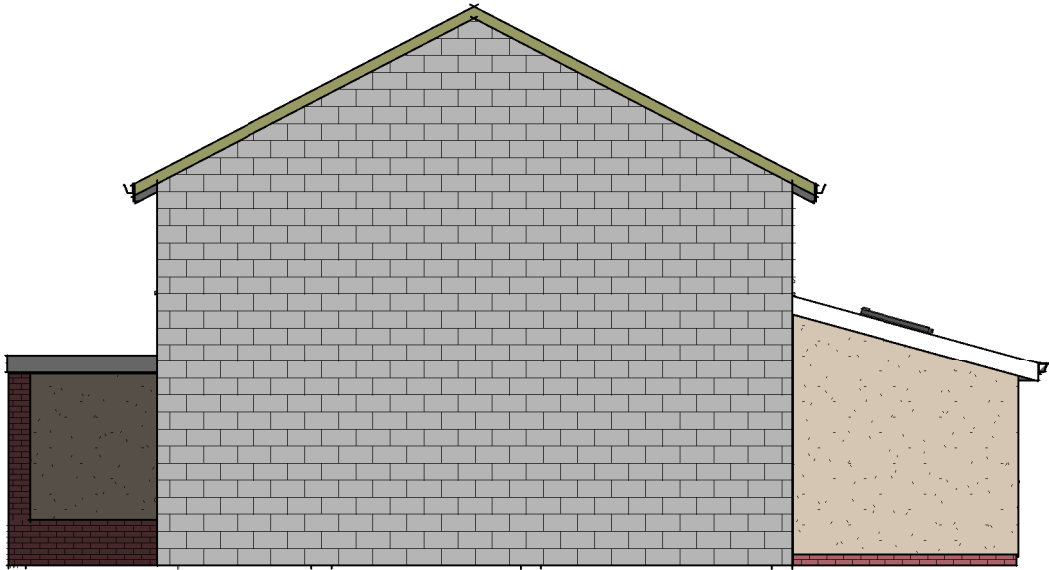


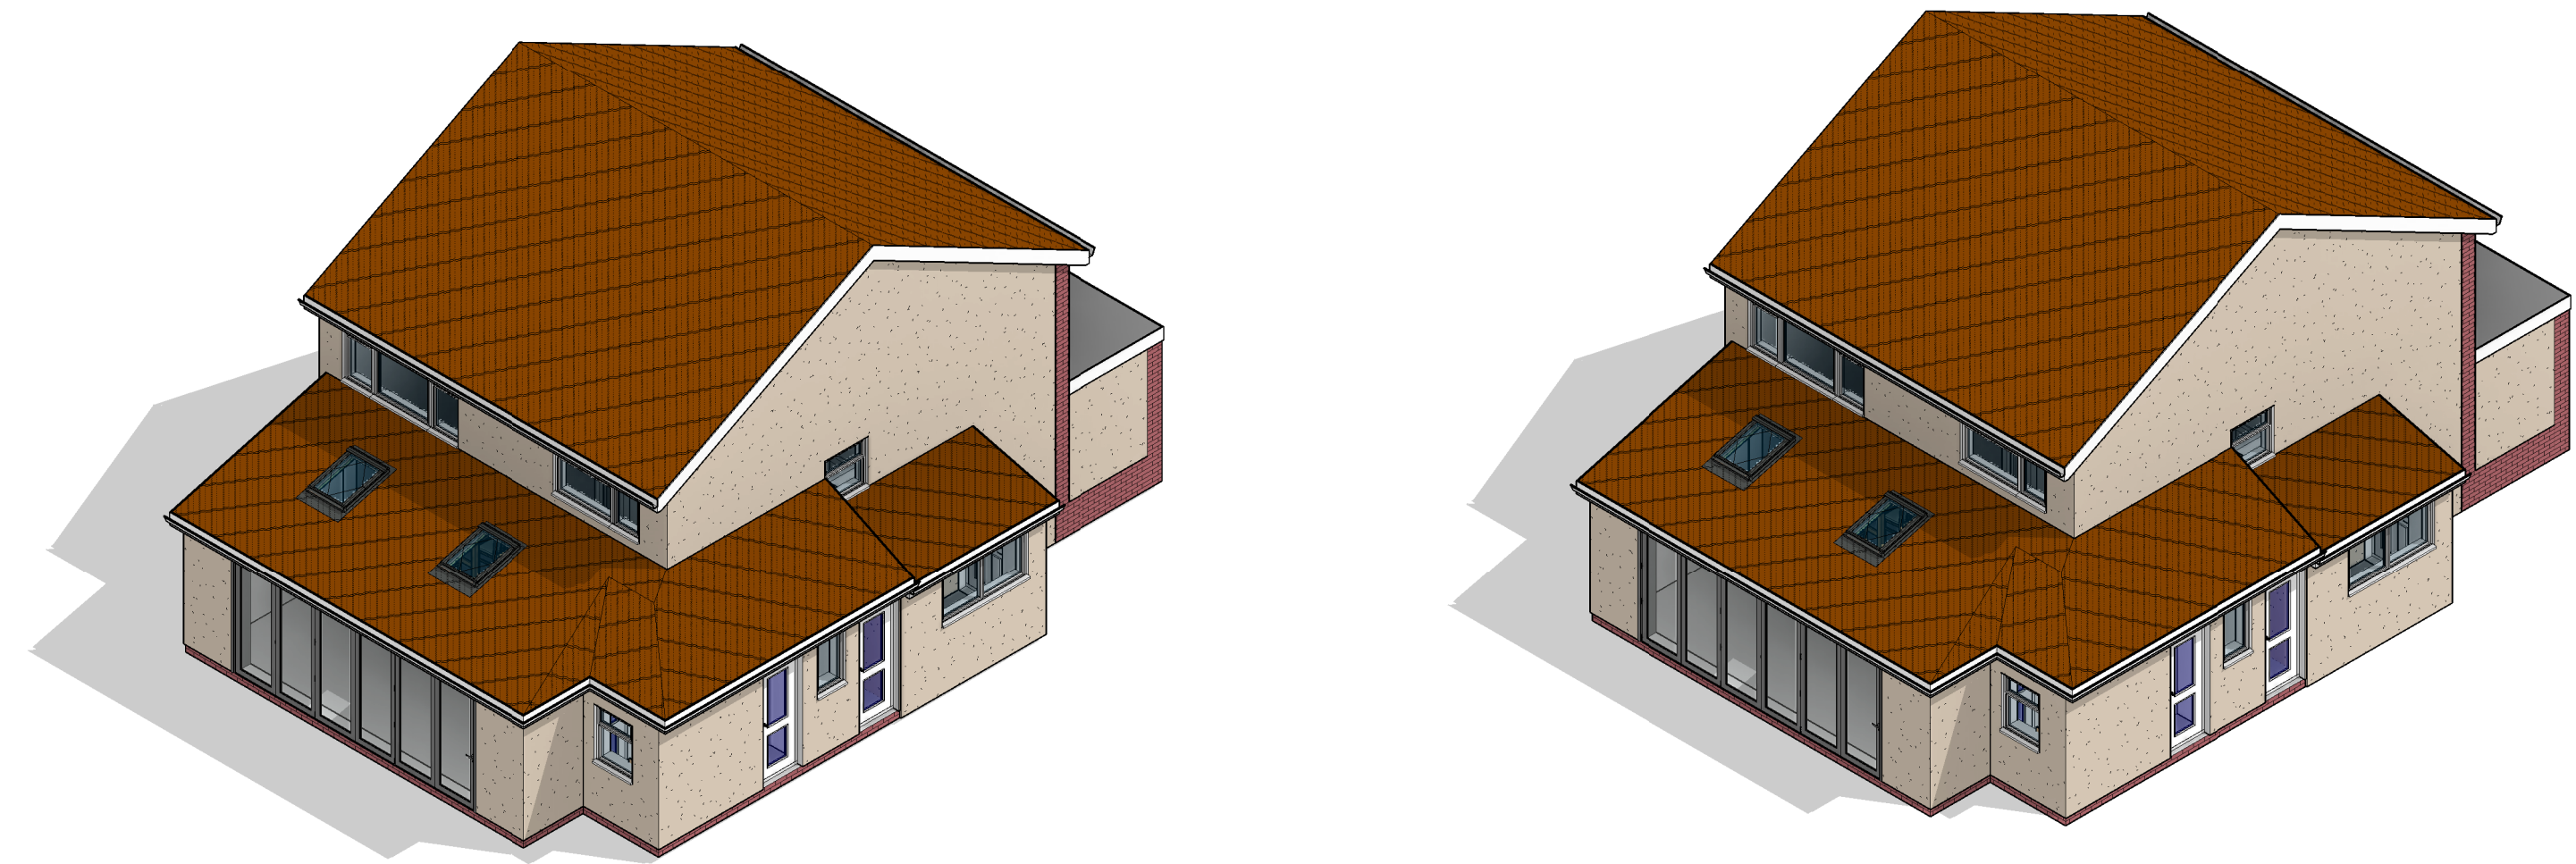

3 Right Side Elevation
1 : 100

1 Single Power Socket	FIRE Fire Alarm Panel	Distribution Board
2 Double Power Socket	SS Shaver Socket	SD Smoke Detector
C Cooker Point	SP Speaker Point	H Heat Detector
Unswitched Fused Spur	TV TV Aerial Point	C Carbon Monoxide Detector
External Power Socket	FB Floor Box	⊗ Extract fan
Telephone Point	FS-2 Floor Socket	○ Underfloor heating control
D Cat 6 Data Point	⊕ Passive Extract	
A Extract Vent	⊕ Mechanical Extract	

Wall Structure Key:


	— Cavity Wall: Render
	— Cavity Wall: Face Brick
	— Block Work: 100mm
	— Studwork Wall: 75mm
	— Metal Frame: 70mm
	— Solid Brick Wall: 215mm
	— Solid Block Wall: 215mm
	— Structural Opening
	— Walls Removed

Drainage Key

S	Storm Drainage
MH	Manhole
FD	Foul Drainage
SVP	Soil Vent Pipe
GP	Gulley Pot
RWP	Rainwater Pipe
AD	ACO Drain

Ducting Colour & Use


Red	Electric cable
Yellow	Gas Pipe
Blue	Water pipes
Green	Data/Comms
Grey	BT
Purple	Security - Cameras
Orange	Garden Lighting non Security

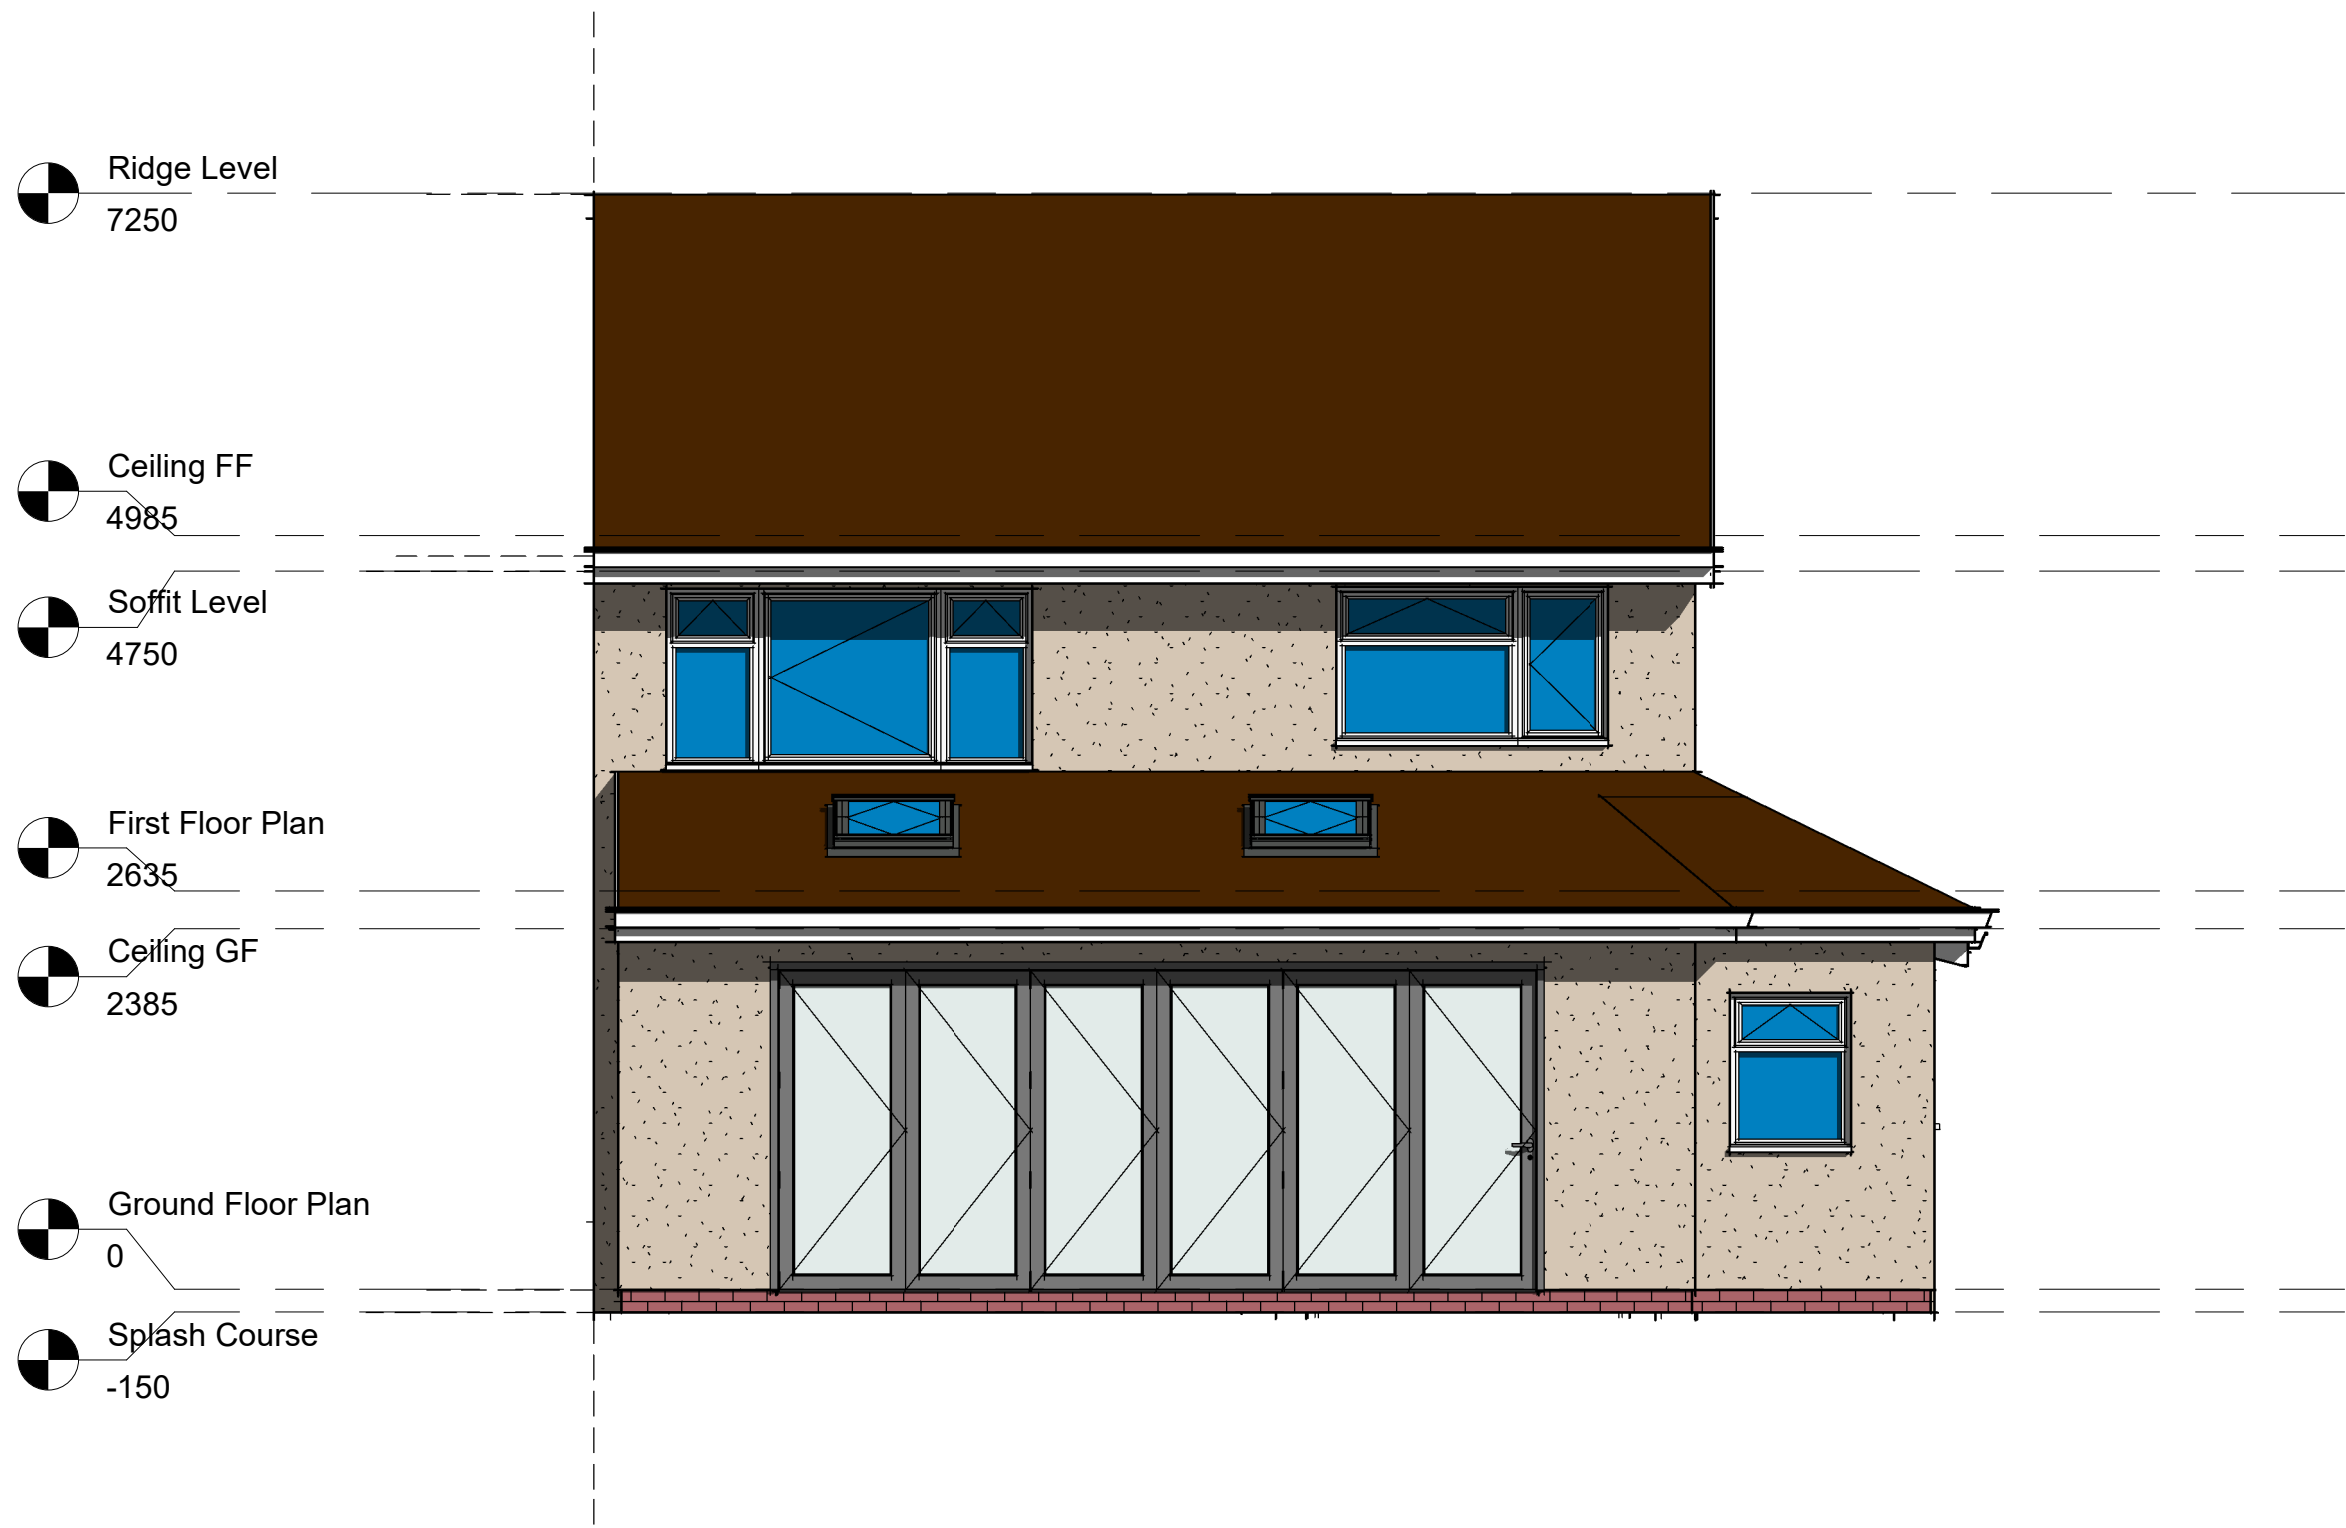


1 Rear Elevation
1 : 50



2 Left Side Elevation
1 : 100

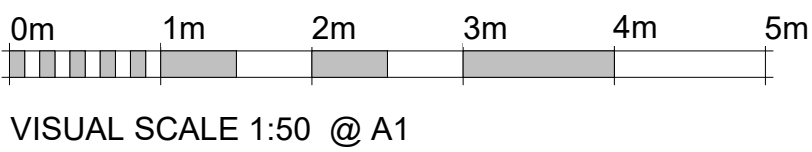

VISUAL SCALE 1:50 @ A1

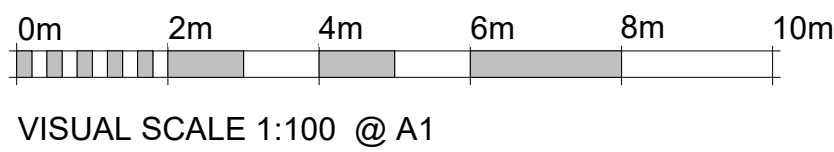

VISUAL SCALE 1:100 @ A1

