
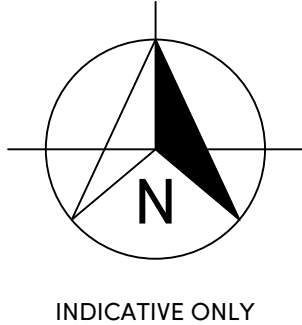


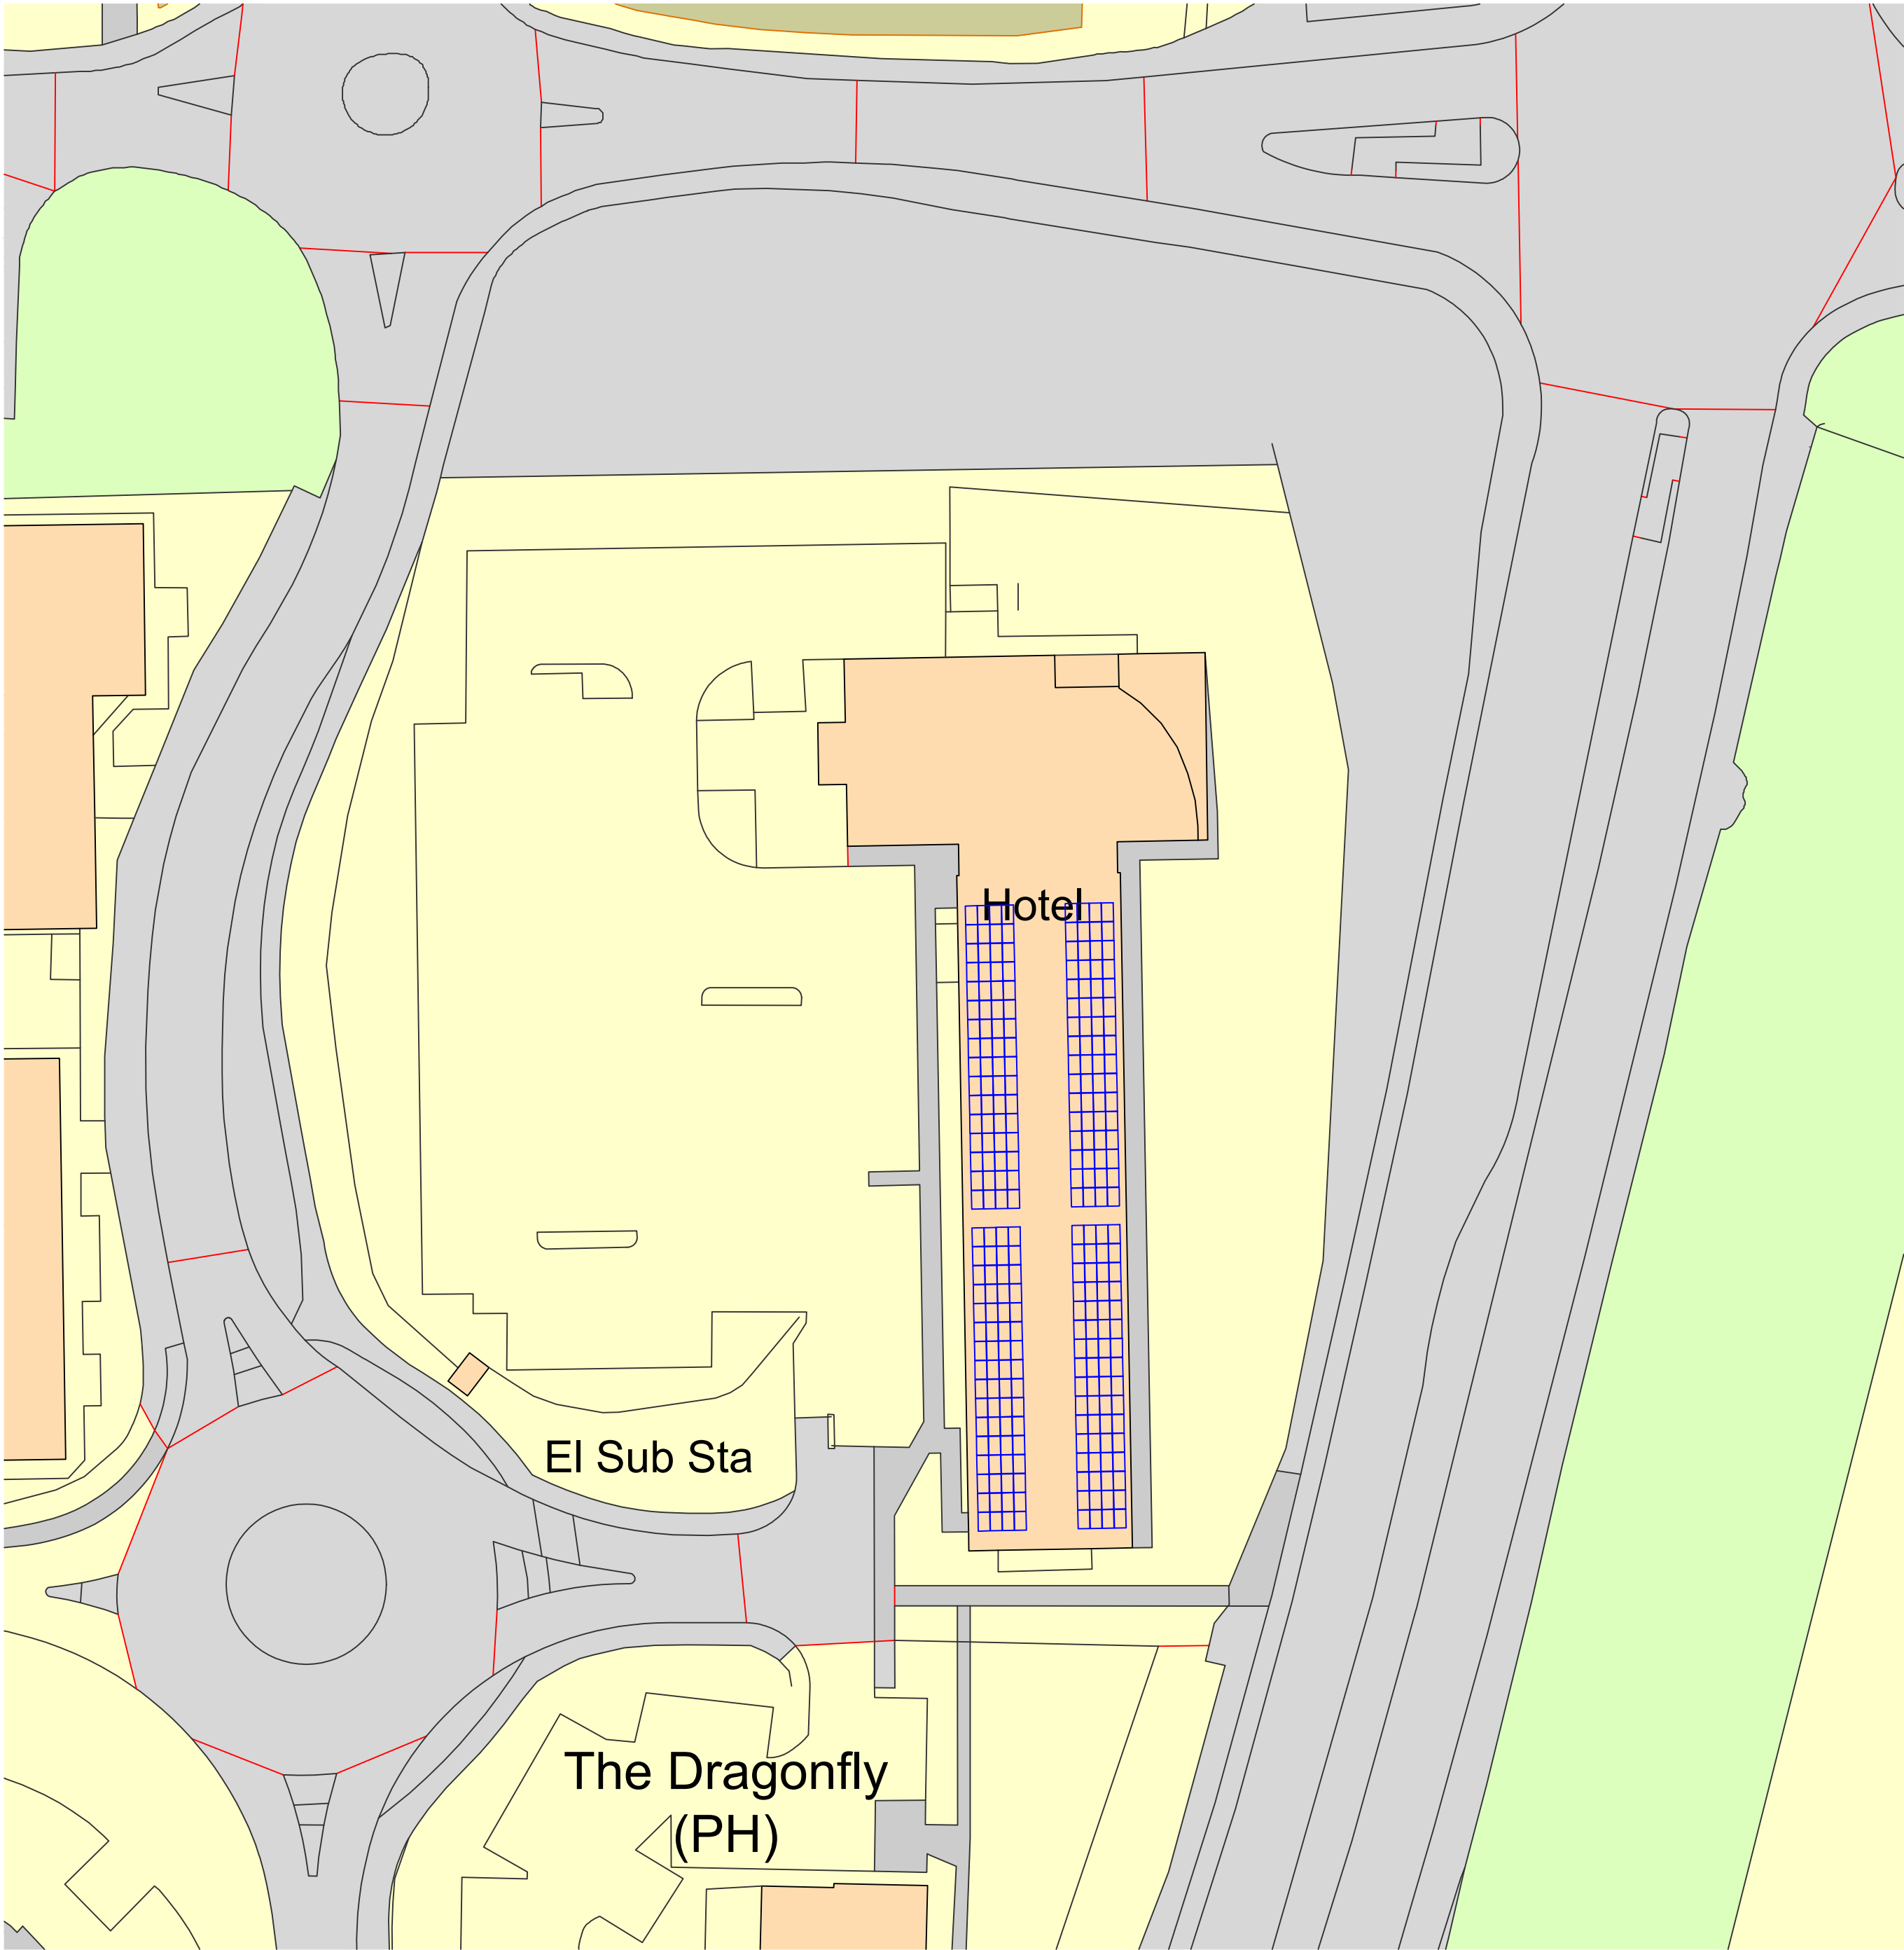


NOTES

- 1) ALL DIMENSIONS TO BE CHECKED ON SITE AND NOT SCALED FROM THIS DRAWING.
- 2) HOLLS SHALL BE INFORMED IN WRITING OF ANY DISCREPANCIES.
- 3) ALL DIMENSIONS ARE IN METRES ONLY.
- 4) THE ORIGIN AND ORIENTATION OF THE SURVEY GRID RELATE TO AN ARBITRARY GRID.
- 5) ALL LEVELS ARE BASED ON AN ARBITRARY DATUM.

KEY

A	Alarm	WB	Handrail
A/C	Air Conditioner	IC	Inspection Cover
AL	Arch Level	ICM	Intersection
ASH	Arch Spring Height	IBF	Iron Bolling Fence
ASL	Arch Spring Level	JB	Junction Box
ATM	Automated Teller Machine	L	Light
B	Bollard	LS	Liter Bin
BGP	Brick Glass Point	M	Maximum
BM	Brick To Beam Height	MMH	Maximum Housch Height
Br	Brick	Min	Minimum
BTW	Brick To Wall	OVH	Overhead
BLL	Brick Soffit Level	OP	Open Standard Fence
BW	Brick Wall	OSM	Ordinance Survey Bench Mark
BWF	Brick Wire Fence	P	Post
CB	Cigarette Bin	PL	Pavement Light
CBF	Chain Bolted Fence	PPF	Post and Rail Fence
CCTV	Closed Circuit Television	PS	Painting Stone
CH	Clear To Head Height	PRF	Post and Wire Fence
Chy	Chimney	R	Rail
CF	Corrugated Iron Fence	RDH	Recessed Door Mat
CH	Clear Internal Height	RH	Ridge Housch Height
CL	Clear Level	R	Road
CLF	Chain Link Fence	RSD	Roller Shutter Door
Col	Column	RJ	Rail Joint
Conc	Concrete	RW	Rain Water Pipe
COW	Cable on Wall	RWC	Rain Water Pipe With Gully
CPS	Concrete Paving Slabs	RWP	Rain Water Pipe
Cup	Cupboard	S	Sign
DH	Down Height	SBR	Site Bench Mark
DP	Down Pipe	SF	Security Fence
DHC	Down Channel	SH	Spring Height
DH	Duct Height	SI	Signpost
EB	Electrical Junction Box	SO	Smoke Outlet
EA	Electricity Meter	SP	Sign Post
ESG	Electrical Switchgear	SS	Security Sensor
FA	Fire Alarm	T	Telephone
FB	Fire Bell	TBM	Temporary Bench Mark
FC	Fire To Ceiling Height	TLS	Threshold Level
FE	Fire Extinguisher	Tye	Top Of Wall
FEL	Fire Extinguisher Level	Typ	Typical
FL	Floor Level	U/L	Under To Lift
FR	Floor	V	Vault
G	Gully	VCP	Vehicle Charging Point
GL	Gully Level	VP	Vent Pipe
GM	Gas Meter	W	Window
GV	Gas Valve	WCL	Window Cill Level
H	Height	WM	Water Meter
HB	Hand Basin	WHL	Window Head Level
		WM	Water Meter

FLOOR PLAN SYMBOLS

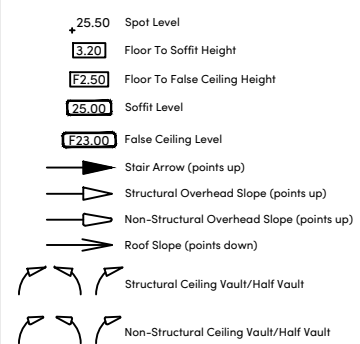

REVISIONS

REV	DATE	AMENDMENTS	INITIAL

THIS DRAWING IS FOR THE FOLLOWING PURPOSE ONLY:
PRELIMINARY ☐ TENDER ☐ CONSTRUCTION ☐
SKETCH ☐ MEASURED SURVEY ☒ CONTRACT ☐

SITE PLAN PROPOSED

CLIENT

Atlas Hotels Limited
4 Romulus Court
Meridian Business Park
Leicester LE19 1YG

PROJECT NAME

Holiday Inn Express
Lakeside Dr, Duffryn
Newport
NP10 8BB

HOLLIS

St Andrew's House
59 St Andrew's Street
Cambridge
CB2 3BZ

T +44 1223 802 990
W hollisglobal.com

DATE	09.06.2026	DRAWN BY	TS
SCALE	1:500 @A2	CHECKED	XX
PROJECT	128449	LINE	105
ORIGINATOR	HLS	VOLUME/ZONE/BLDG	00
LEVEL	RF	FILE	M2
DISCIPLINE/TYPE	B	NUMBER	10200
STATUS	S0	REVISION	P00