



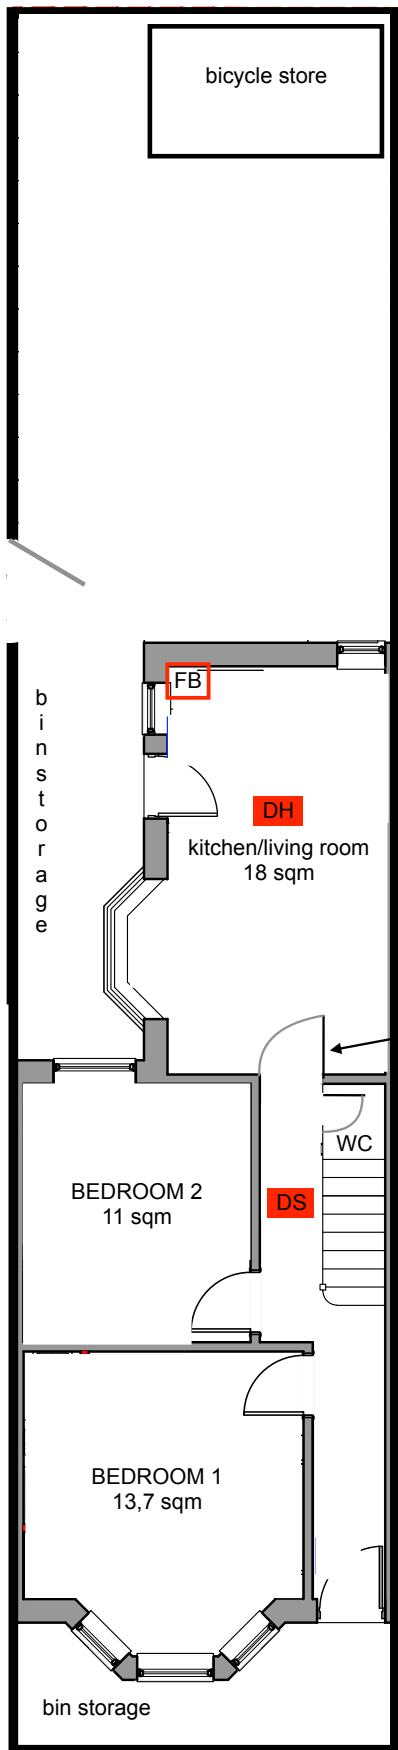

GROUND FLOOR PLAN AS PROPOSED

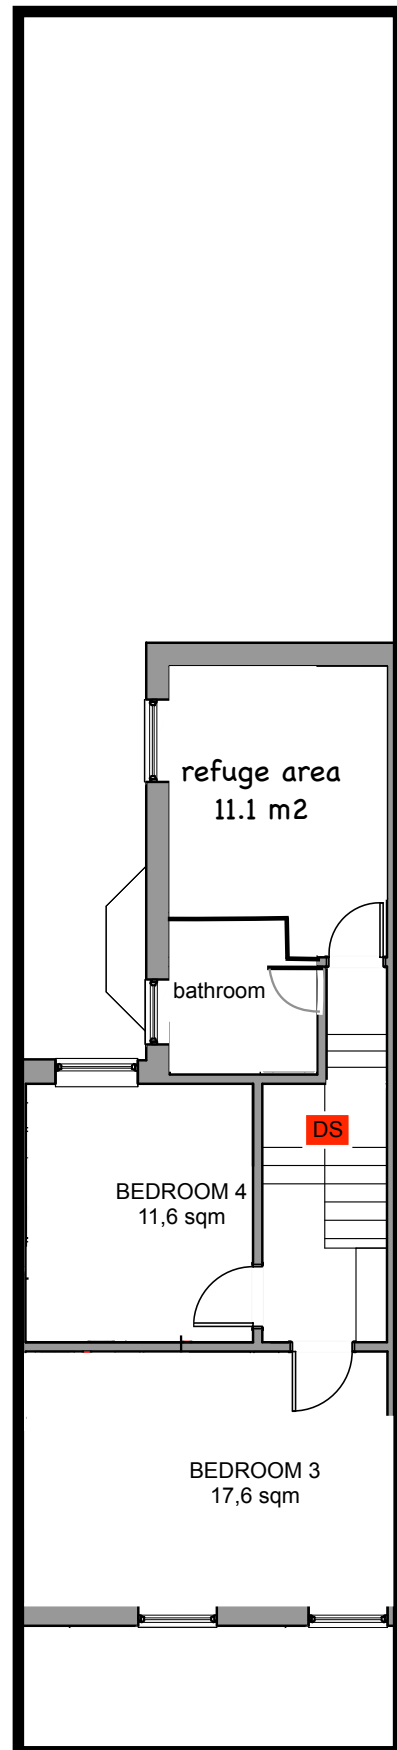

FIRST FLOOR PLAN AS PROPOSED

DS mains wired interlinked smoke detector
 DH mains wired interlinked heat detector
 FB fire blanket

Scale 1:75 @ A3