

GENERAL NOTES


1. This drawing is to be read in conjunction with and checked against all other drawings, engineering details, specifications and any structural, geotechnical or other specialist document provided.
2. Any discrepancies within all relevant drawings are to be reported to QuadConsult Ltd immediately.
3. All dimensions and levels are in metres, U.N.O.
4. Do not scale from this drawing - use figured dimensions only.
5. This drawing is schematic for clarity only, positions of pipe runs and manholes may vary on site due to site conditions.
6. Surface water drainage subject to S104 / SAB approval where appropriate with the relevant authority.
7. Foul Drainage subject to S104 approval with relevant water authority.
8. All private drainage to be installed in accordance with Part H of building regulations and the developers warranty provider.
9. The contractor is at risk if construction is progressed without relevant S104, S106, S278, S38, OWC etc agreement being in place with the relevant authorities.

STREET LIGHTING LEGEND

- STREET LIGHTING COLUMN MAIN HIGHWAYS
- STREET LIGHTING COLUMN CYCLE PATHS
- STREET LIGHTING (EXISTING) SPINE ROAD
- SHARED DRIVE LIGHTING - BOLLARD POSTS OR SIMILAR

NOTE - STREET LIGHTING COLUMNS/ BOLLARD POSTS ARE SHOWN FOR INDICATIVE PURPOSES ONLY AND SUBJECT TO DETAILED DESIGN.

MATURE HEIGHT AND CANOPY OF PROPOSED TREES TO BE CONSIDERED AT DETAILED DESIGN TO ENSURE LIGHTING IS NOT AFFECTED.

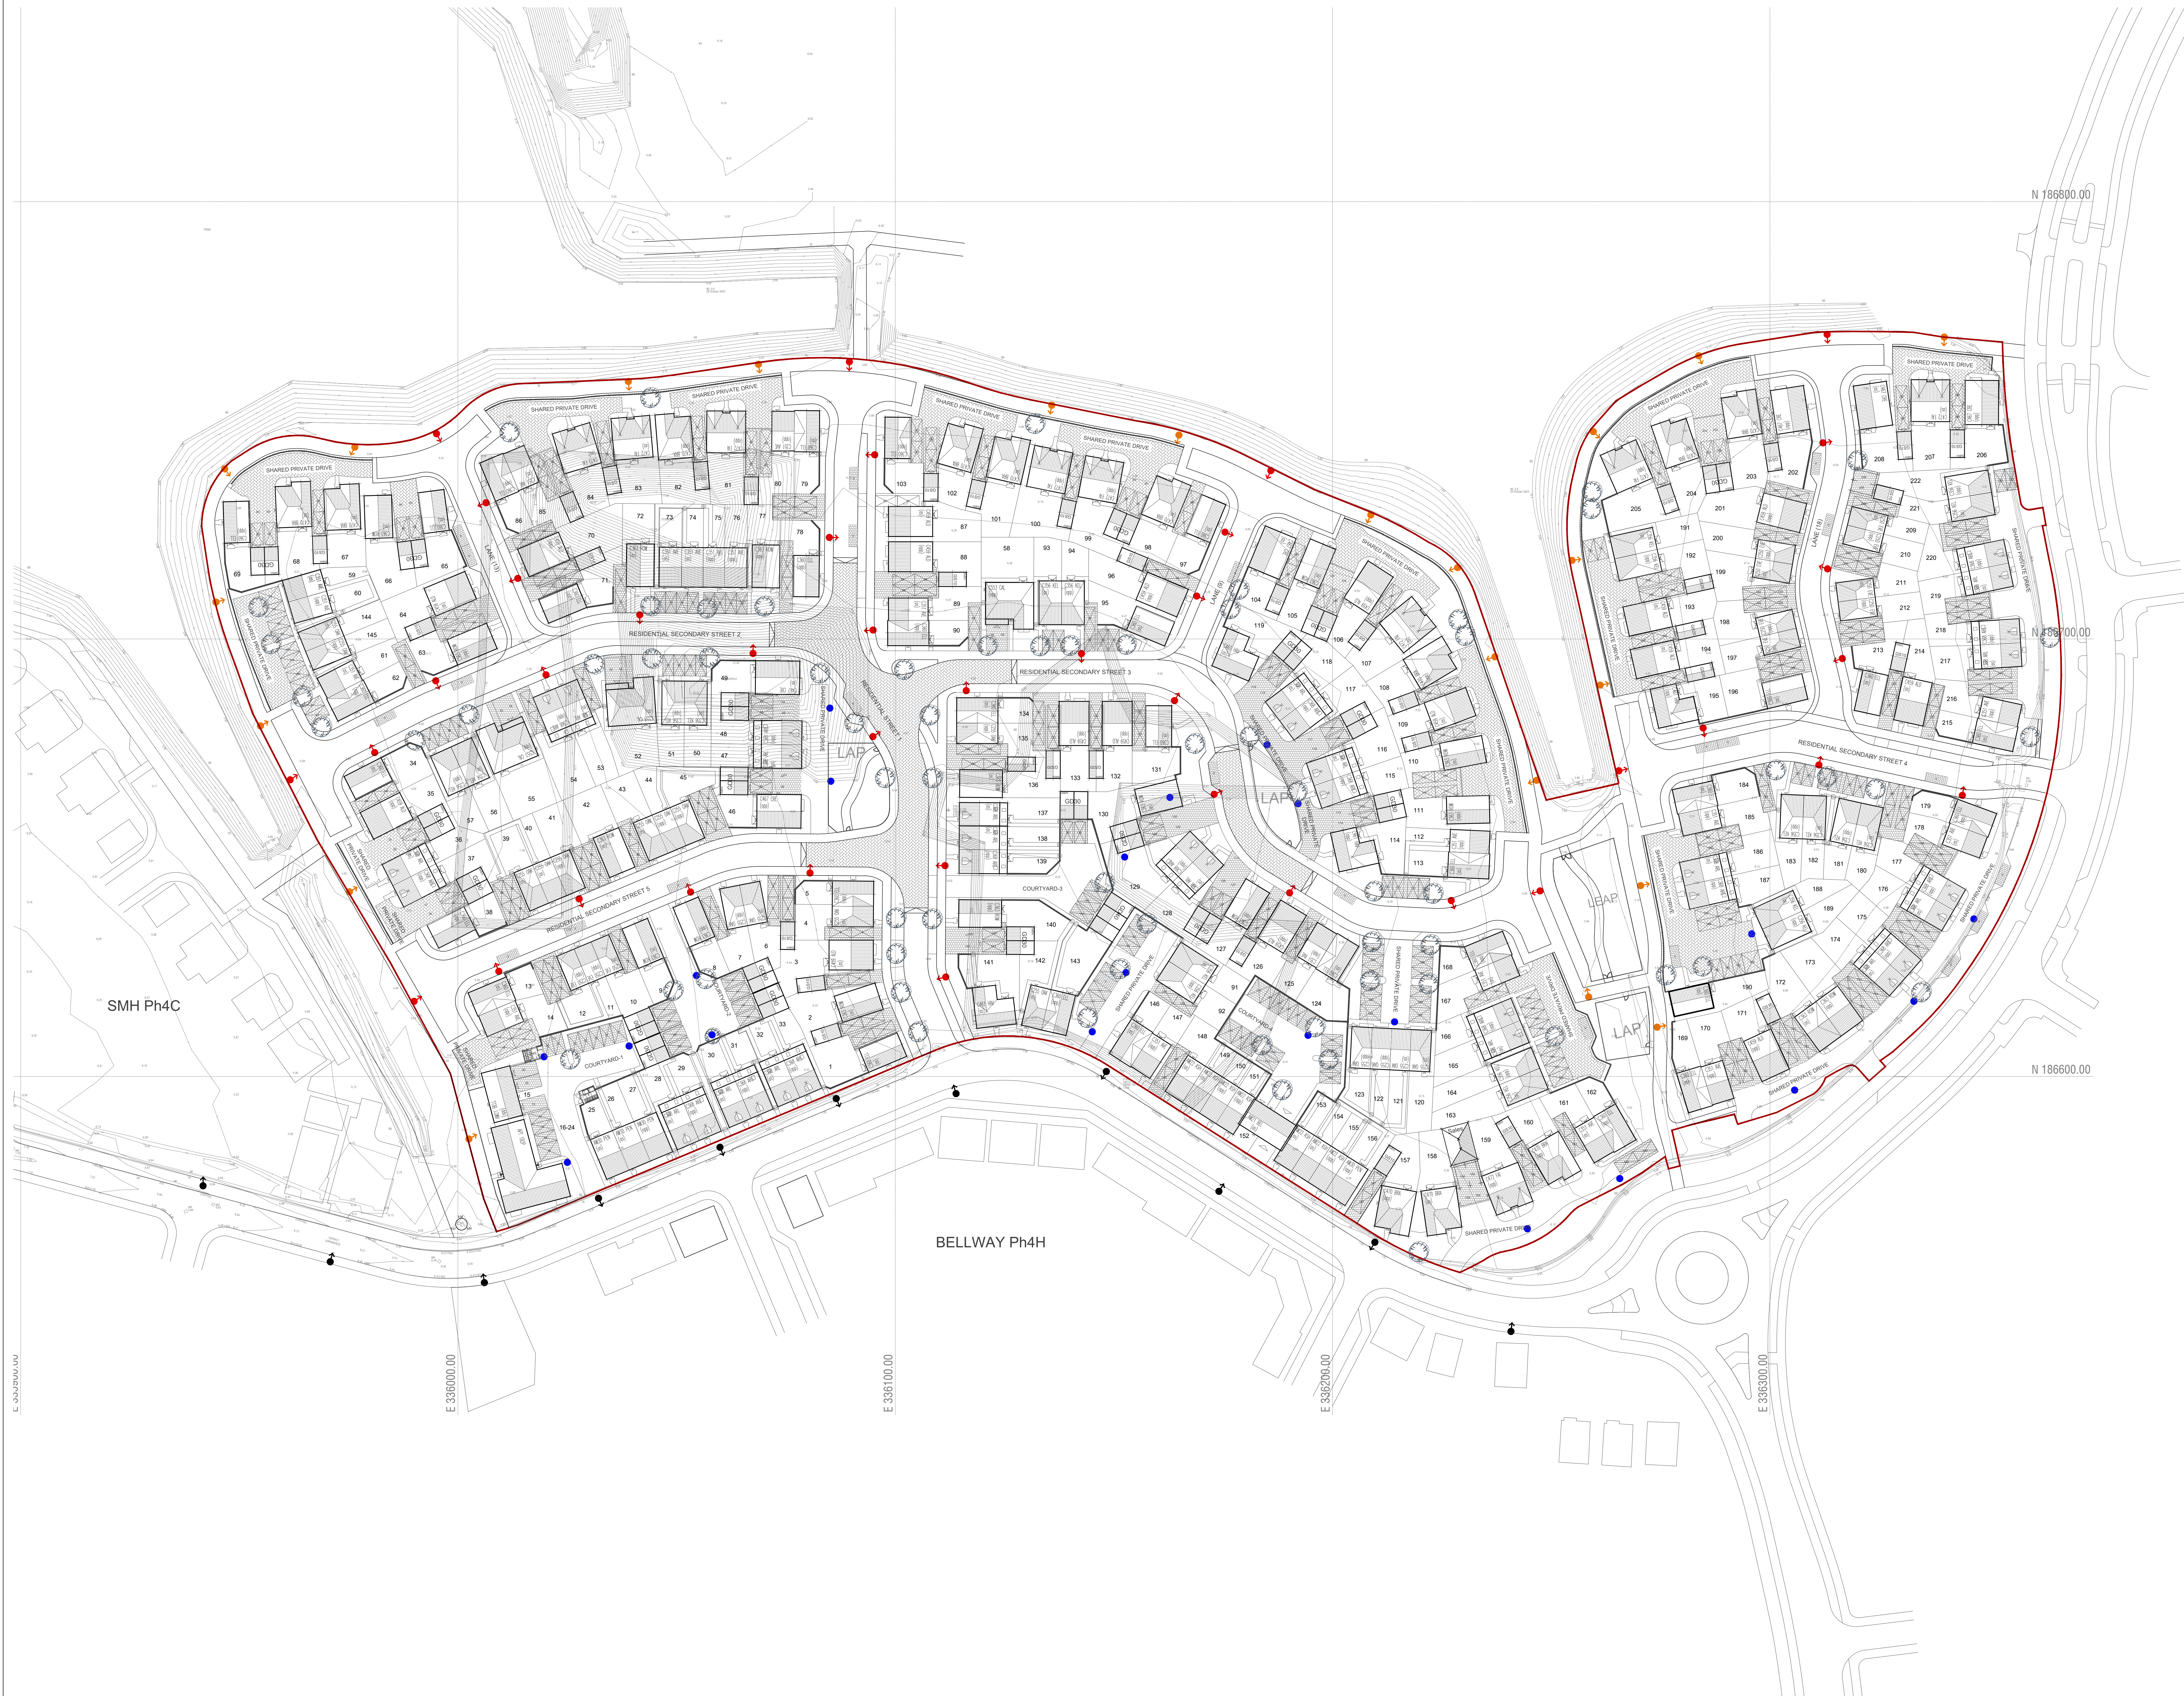

T1	03.06.26	Plan amended to suit latest layout	RWP
D	26.03.26	Plan amended to suit latest layout	RWP
F	14.01.26	Additional Parking Court Lights added	RWP
E	14.12.25	Adjustment to Parking Court - page 16/23	TJ
D	04.12.25	Site Layout Updated	SLS
C	28.11.25	Site Layout Updated - Shared Surface Areas Illuminated with Bollard Posts	RWP
B	13.10.25	Plan amended to suit latest layout	RWP
A	02.09.25	Site Layout Updated	RWP

Dimensions to be verified on site.
This drawing should not be scaled. Use figured dimensions only.
Any discrepancies should be referred to the Engineer prior to work being put in hand.
This drawing is copyright.

QuadConsult Limited
Columbus House, Village Way
Greenwood Business Park
Cardiff
CF15 7NE
029 2077 9644
enquiries@quadconsult.co.uk
www.quadconsult.co.uk
Consulting Civil & Structural Engineers
Offices in Cardiff, Gloucester and Llanidloes



MILLER HOMES

LLANWERN 4E & 4G

Street Lighting Layout
- Planning

PLANNING

Designed by	Drawn by	Checked by	Date	Scale & A1 size
RWP	RWP	ACV	Feb 25	1:500

Drawing No

24519-C-025-H