


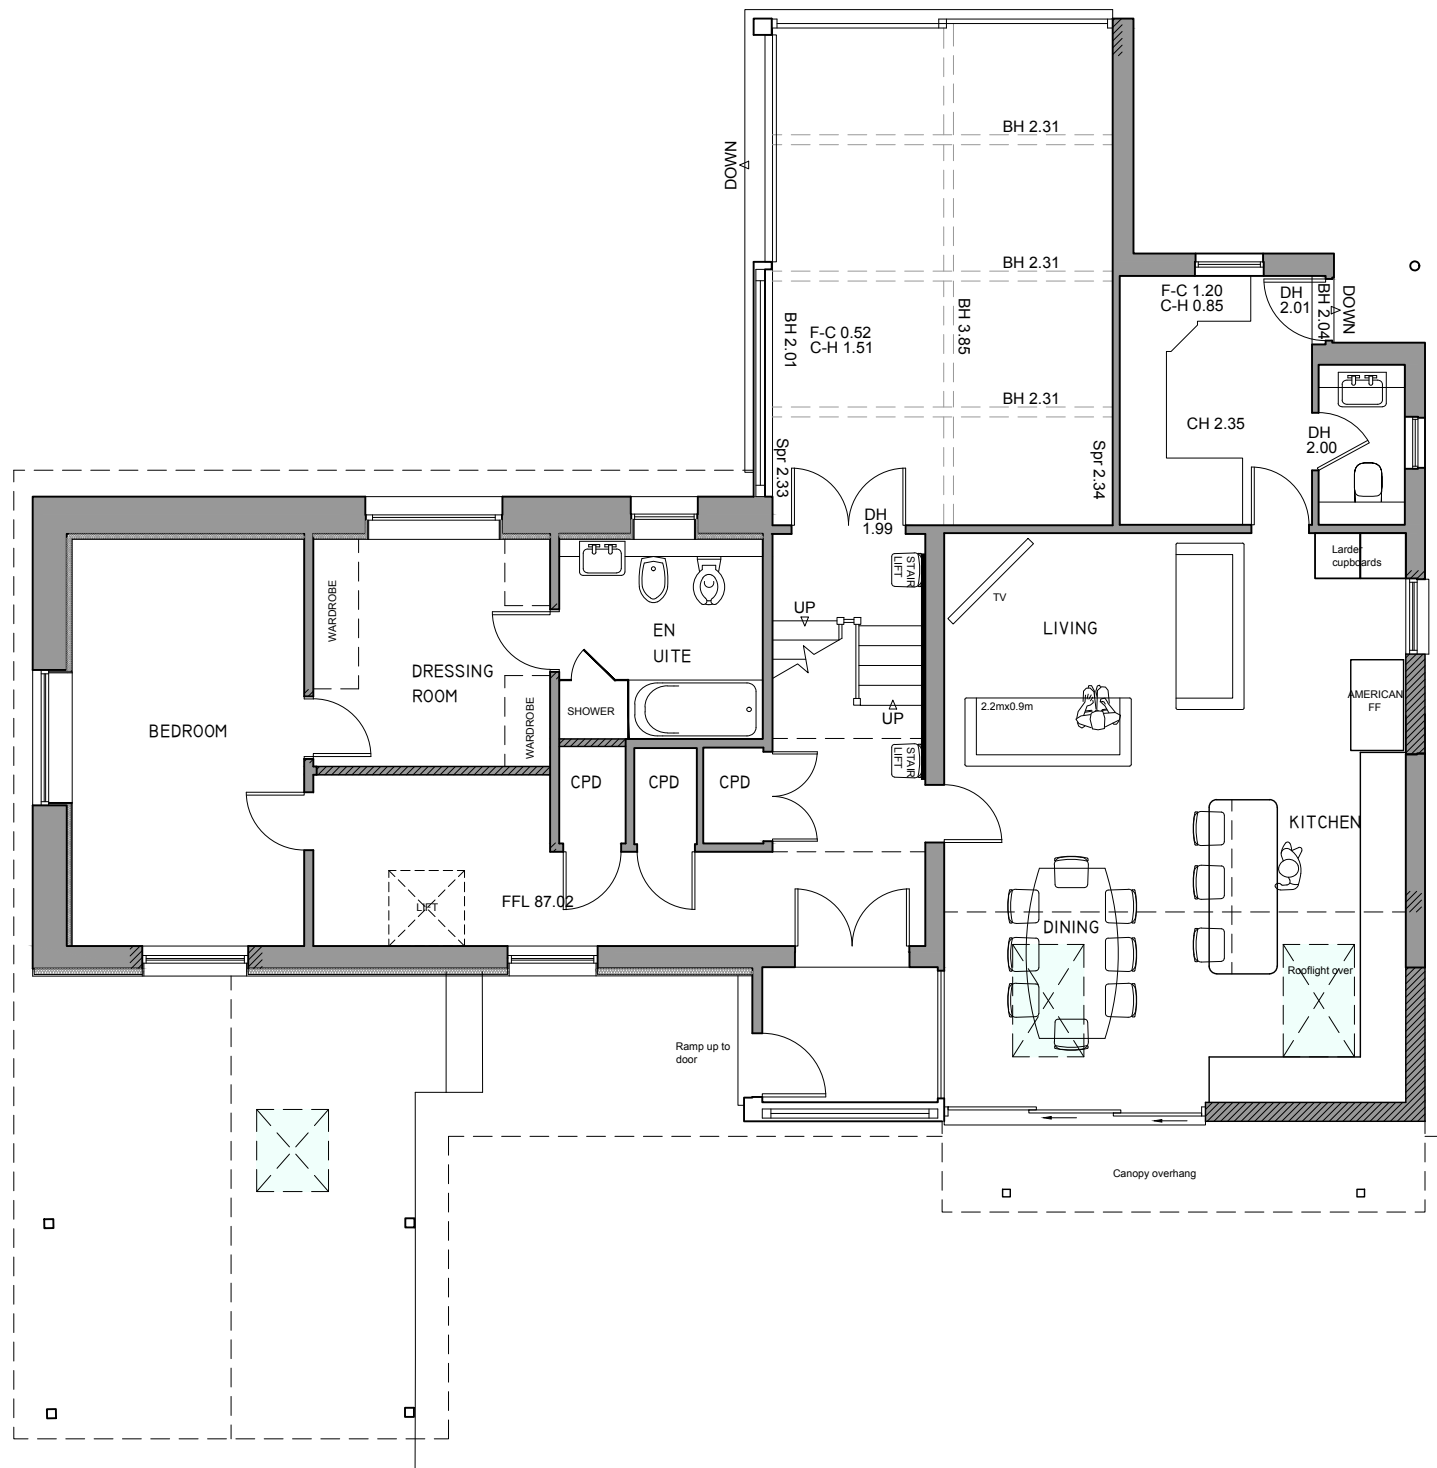

Ground Floor Plan

scale 1:100



First Floor Plan

scale 1:100



STEVE JACKSON DESIGN LIMITED

SUITE 32 | PHILPOT HOUSE | STATION ROAD | RAYLEIGH | ESSEX |
SS6 7HH

T: (01268) 745 069 E: STEVE@STEVEJACKSONDESIGN.CO.UK

Client:

MR & MRS WINTER

Location:

Location:
RECTORY COACH HOUSE
MICHAELSTON-Y-FEDW
CARDIFF
CF3 6XS

Project:

PROPOSED PLANS

Drawn: AM

Checked:

Date: APR 25

Scale: 1:100

Drawing Size: A3

Drawing No: 0621487-L01

Revision:

This drawing is copyright of Steve Jackson Design Limited, no unauthorised copying without prior consent.
All dimensions are to be checked on site and the Architect notified of any discrepancies.
Do not scale from this drawing for construction purposes.

All levels and dimensions are approximate

