

LEGEND

EX1



COLUMN MOUNTED LED LUMINAIRE, WITH ZERO UPWARD LIGHT SPILL
MOUNTING HEIGHT 8M
LUMINAIRE IS FITTED WITH AN ASYMMETRIC LIGHT DISTRIBUTION
AS HOLOPHANE LIGHTING 'D-SERIES 0' LUMINAIRE 114W, 15510LM, 4000K

EX2



COLUMN MOUNTED LED LUMINAIRE, WITH ZERO UPWARD LIGHT SPILL
MOUNTING HEIGHT 8M
LUMINAIRE IS FITTED WITH A LONG AND NARROW THROW LIGHT DISTRIBUTION
AS HOLOPHANE LIGHTING 'D-SERIES 0' LUMINAIRE 56W, 8276LM, 4000K


1000 DUCT FOR STREET LIGHTING

FEEDER PILLAR

EX3 EXISTING EXTERNAL ROAD LIGHTING

NOTES

1. NEW LV METERED SUPPLY FOR STREET LIGHTING TO BE CONFIRMED VIA SSE NETWORKS.

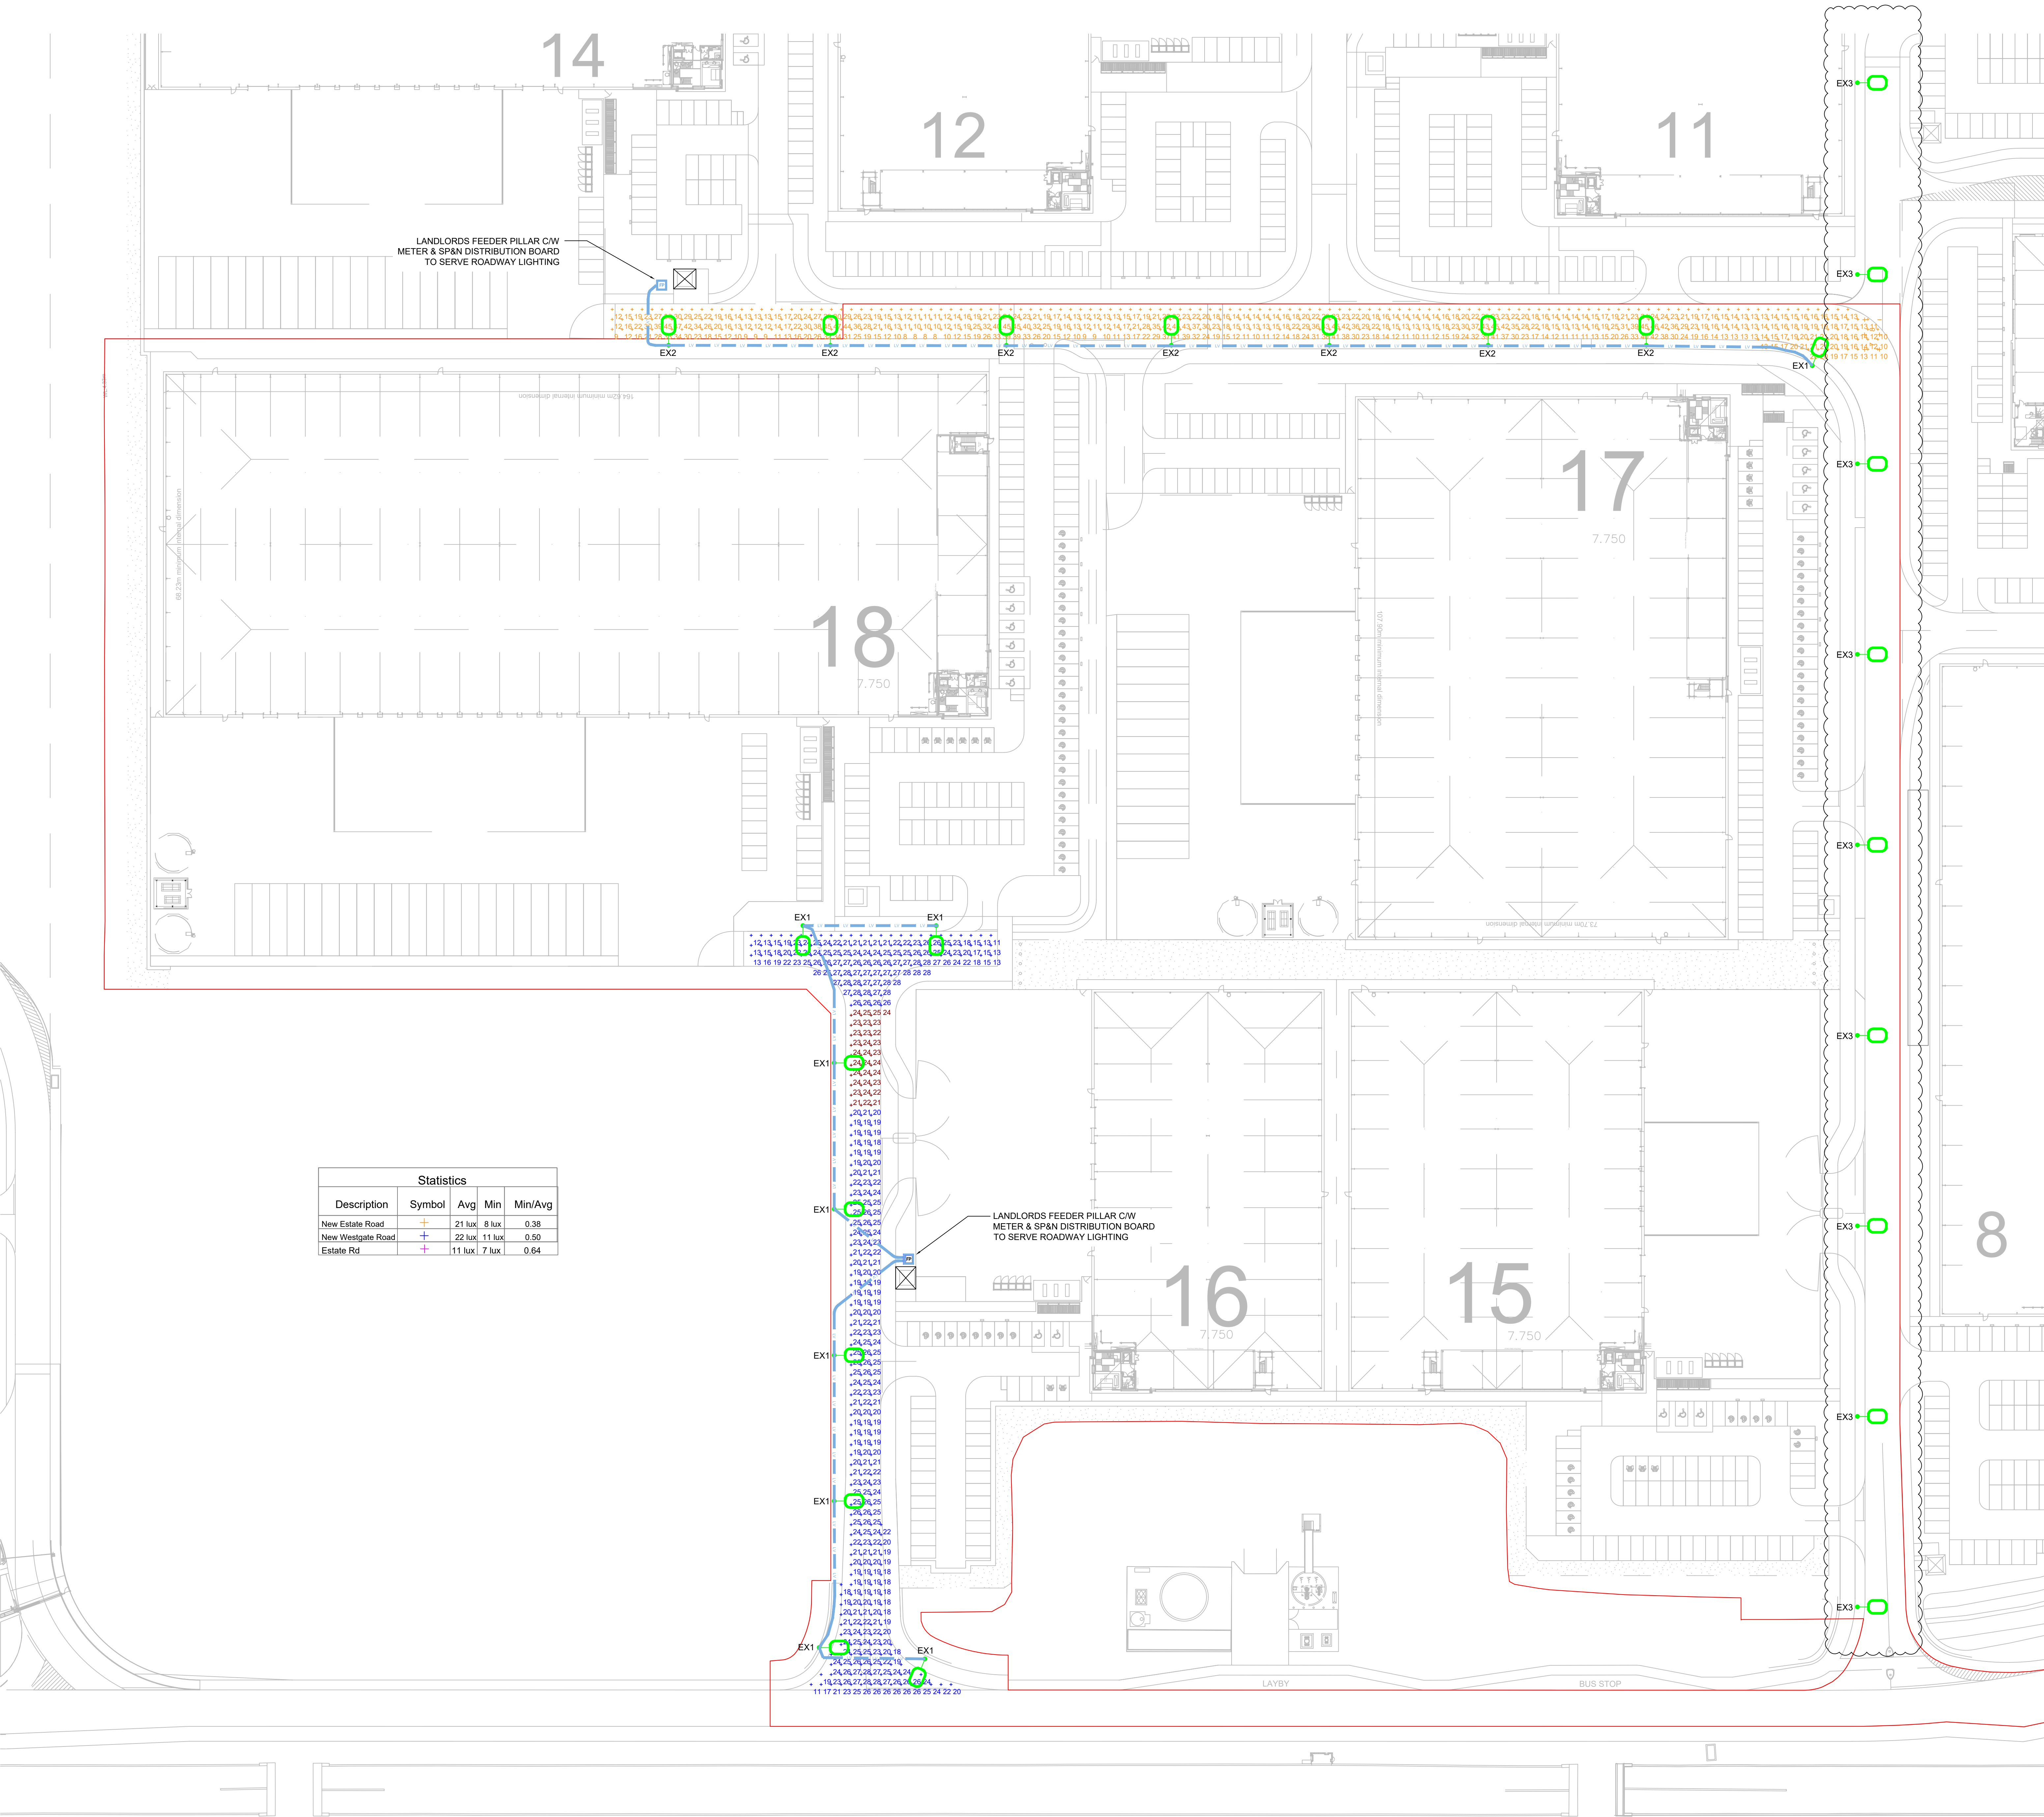

STAGE 3

Status

TENDER

Client



Project

INDURENT PARK NEWPORT

Drawing Title

ROADWAYS EXTERNAL LIGHTING LAYOUT

Scale (A3) Date By Ve
1:500 MAY 25 CM DP

240234 CPW XX EX1 DR E 221004 SO T02

240234-CPW-XX-EXT-DR-E-221004 SO T02

CPW Project No. 240234

Linked Files