


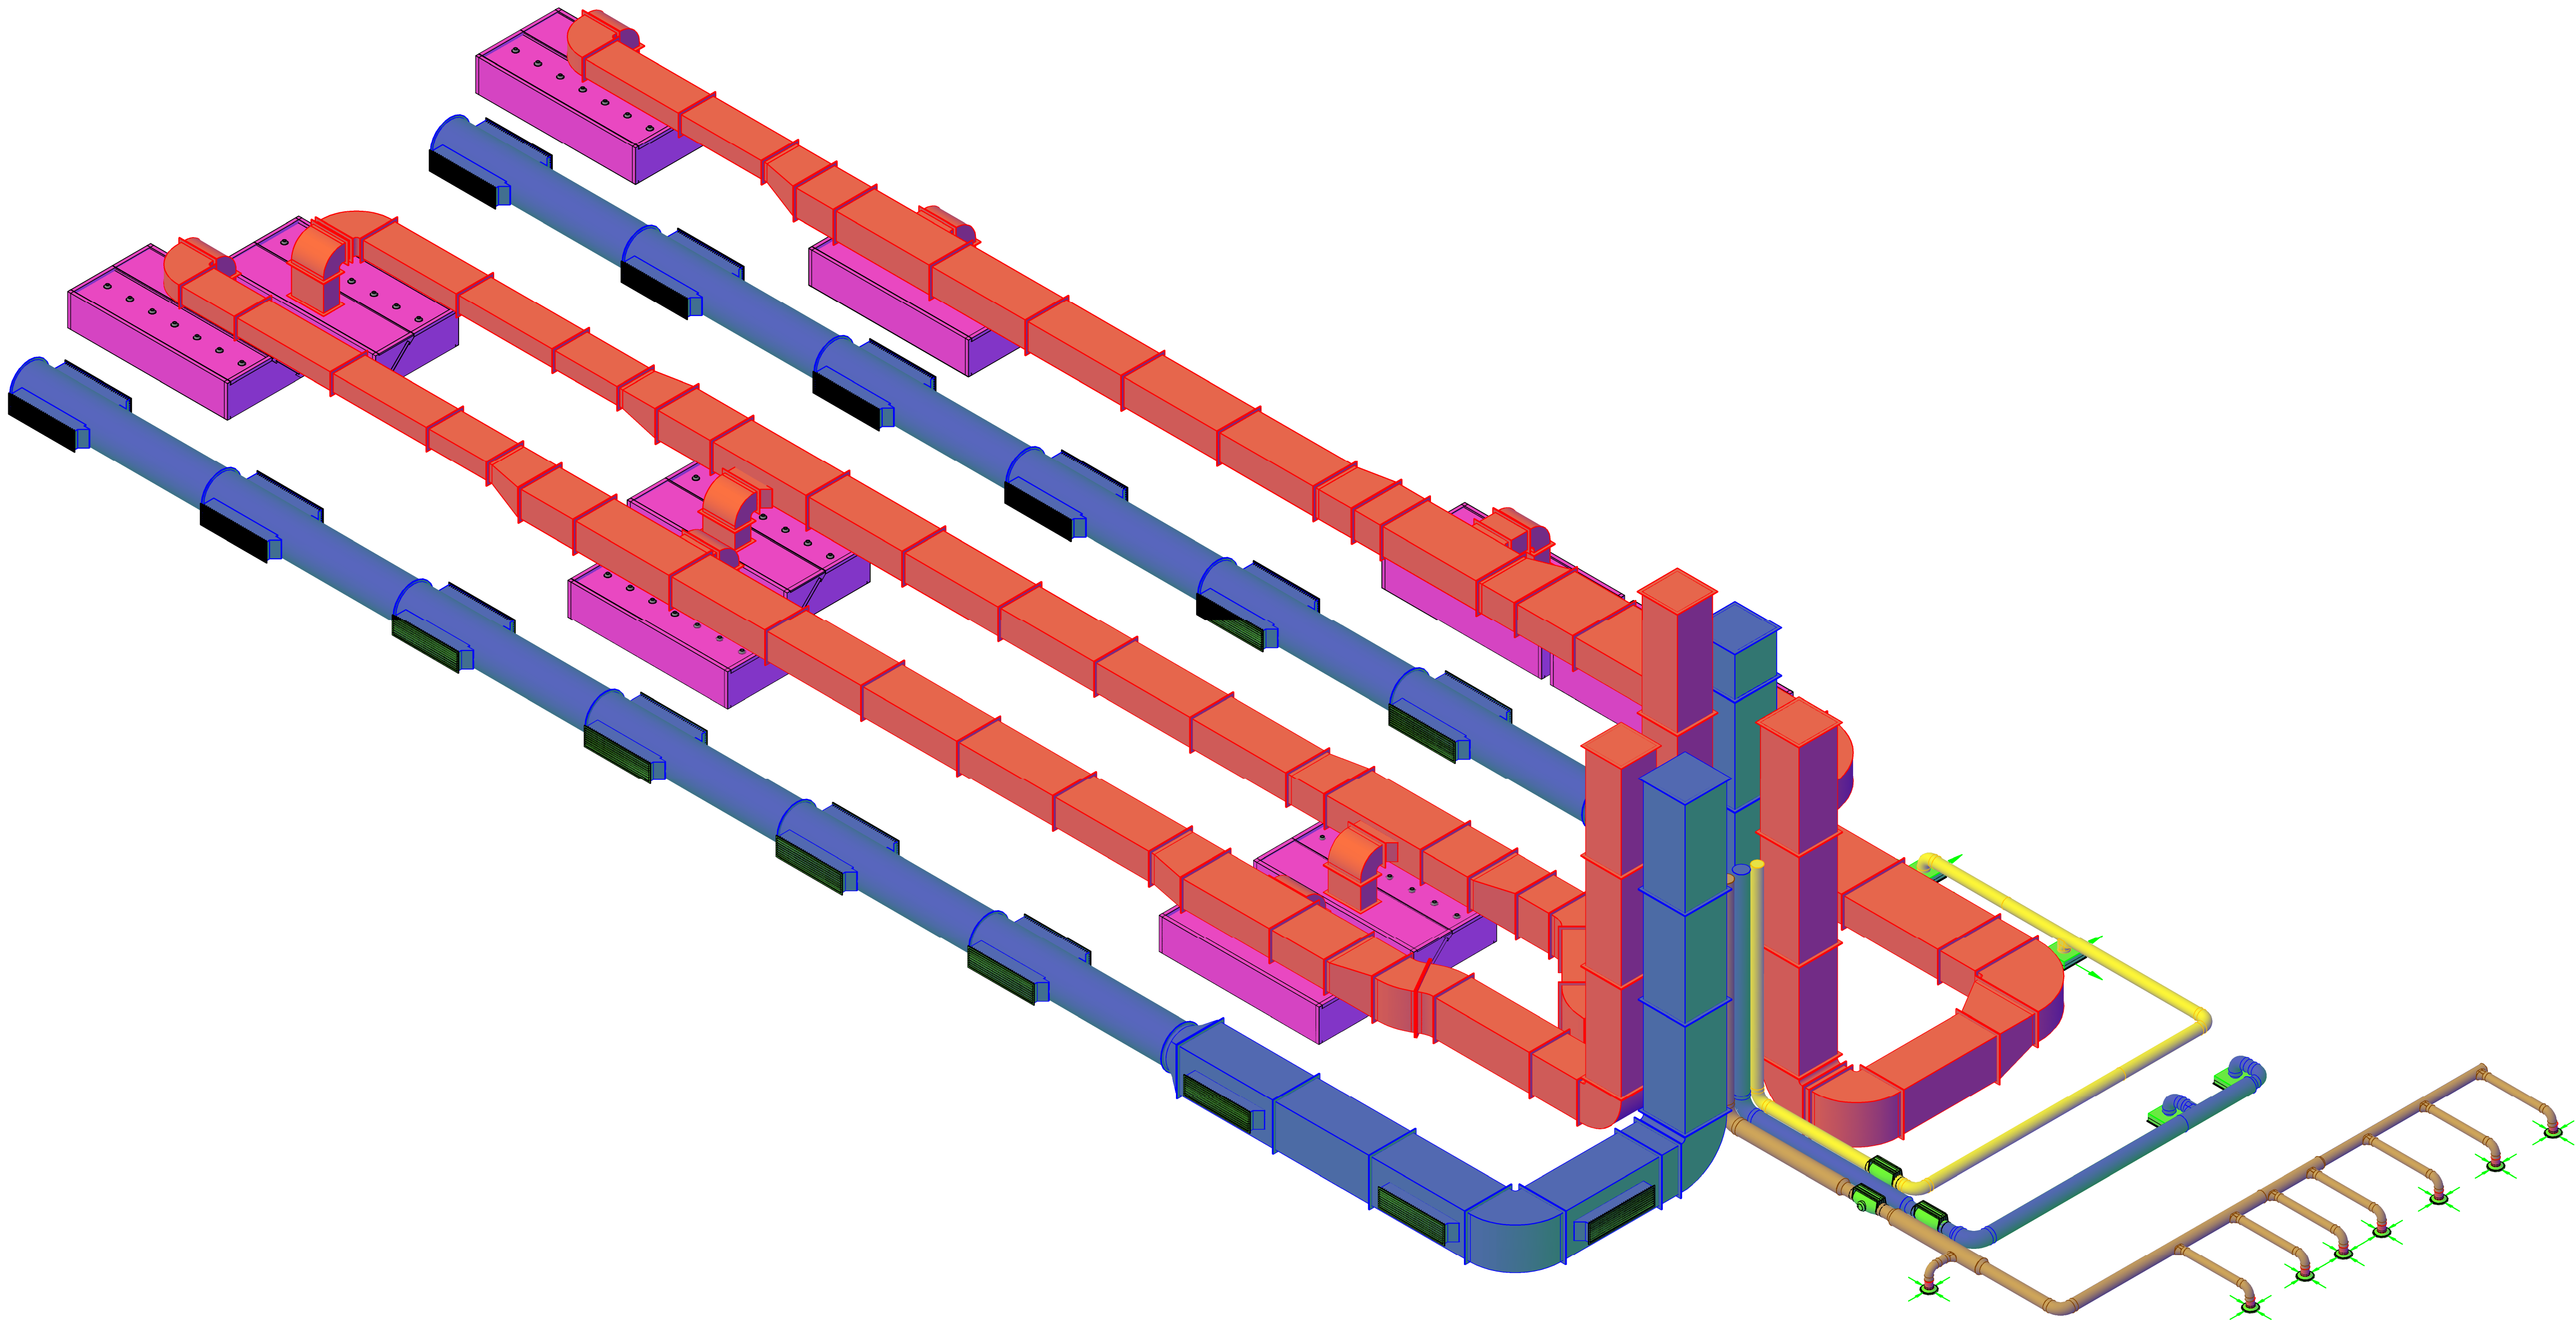

00

Ground Floor Ventilation Visual

Scale: 1:50



All dimensions in mm

Notes

Final connections to the equipment will be made to suitably terminated services provided within 1m of the equipment by the main contractor.

WATER:- Where blended, or max / controlled temperature supplies are required, or blending or mixing is required to suit byelaws, mixing and temperature control valves should be supplied by the main contractor. Where treated water is called for, this indicates a requirement for conditioned drinking water, treated by a food-safe method.

Suitable substrate is to be provided to support wall hung equipment.

CES are competent in the engineering design, specification and installation of the canopy and ductwork systems that we quote. We are not however competent in assessing the suitability and stability of existing structures in supporting the same and have not included for the provision of third party assessment of structural stability or secondary steels or supports

Please note: These drawings are provided to aid in the setting out and provision of services only. The equipment shown is indicative only of the manufactured product. For fabrication detail please refer to manufacturing drawings.

All electrical requirements to meet CESRB recommendations

The information on this drawing shows design intent ONLY and must be verified by the foodservice equipment contractor, unless clearly stated otherwise.

Responsibility is not accepted for errors made by others scaling from this drawing. All construction information should be taken from figured dimensions only.


Details and sizes shown are indicative only and are subject to confirmation by the relevant sub-contractor.

It is the contractors responsibility to check all dimensions on site.

Any discrepancies or items where dimensions cannot be determined should be reported to MDC.

Any information issued by MDC in digital format is copyright and issued solely for the addressee and for the project titled.

Site Plan: 1:500

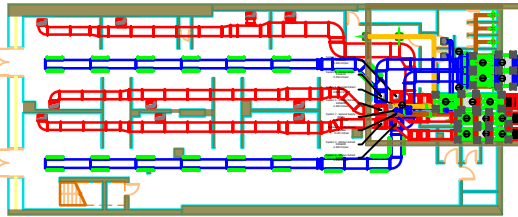

|     |                               |            |
|-----|-------------------------------|------------|
|     |                               |            |
|     |                               |            |
| B   | Third Floor/Roof Layout Added | 29/07/2025 |
| A   | Initial Layout                | 15/06/2025 |
| Rev | Description                   | Date       |



|                                                      |                       |
|------------------------------------------------------|-----------------------|
| <b>Project Name:</b><br>11 Commercial Street Newport |                       |
| <b>Drawing Title:</b><br>Ventilation Visual          |                       |
| <b>Area:</b> Ground Floor                            |                       |
| <b>Level:</b> 00                                     | <b>Grid:</b> Xxxx     |
| <b>Scale:</b> 1:50 @ A1                              | <b>Status:</b> Xxxx   |
| <b>Date:</b> 29/07/2025                              | <b>Drawn by:</b> SB   |
| <b>Purpose of issue :</b>                            |                       |
| <b>Drawing Number:</b><br>CSN-MDC-XX-00-DR-H-4005    | <b>Revision:</b><br>B |