

Cable Depths provided by contractor

Granular pits dug for cables
Location of cable to be marked by marker tape

Notes

- All dimensions are in millimetres unless otherwise stated.
- Equipment details and dimensions are based on information supplied to Mott MacDonald from manufacturer's suppliers or the client.
- Any drawing errors or discrepancies should be brought to the attention of Mott MacDonald.
- The designs shown are subject to detailed site investigations, the CDM Regulations and review of Statutory Undertakers available information, etc.
- This drawing is to be read in conjunction with all other submitted documents and drawings.
- No unauthorised use, disclosure, storage or copying.

Key to Symbols

- Ground level
- Below ground level
- Dimensions
- Marker tape
- Power ducting
- Data only ducting

Reference Drawings

For the location of proposed equipment and site-specific details, please refer to the Proposed Equipment Key included on the Proposed Site Plan drawings.

P01	21.08.2025	JLT	Preliminary Issue	LA	CW
Rev	Date	Drawn	Description	Ch'k'd	App'd

Status Stamp

M

MOTT
MACDONALD

St Vincent Plaza
319 St Vincent St
Glasgow, G2 5LP
United Kingdom

T +44 (0)141 222 4500
F +44 (0)141 221 2048
W www.mottmac.com

Client


The National Trust
Heelis
Kemble Drive
Swindon
SN2 2NA




Ymddiriedolaeth
Genedlaethol
National Trust

Title
National Trust Car Park Infrastructure
Proposed Equipment Detail
Power and Data Cable Depths


Designed	J. L. Taylor	JLT	Eng. Check		
Drawn	J. L. Taylor	JLT	Coordination		
Dwg. Check	L. Amabile	LA	Approved	C. Way	CW
MMD Project Number	Scale at A1		Seq. Number	Security	
100124714	1:2				STD
Suitability Description				Suit. Code	
Suitable for Review and Comment				S3	
Drawing Number				Rev	
100124714-MMD-00-XX-DR-A-2010				P01	

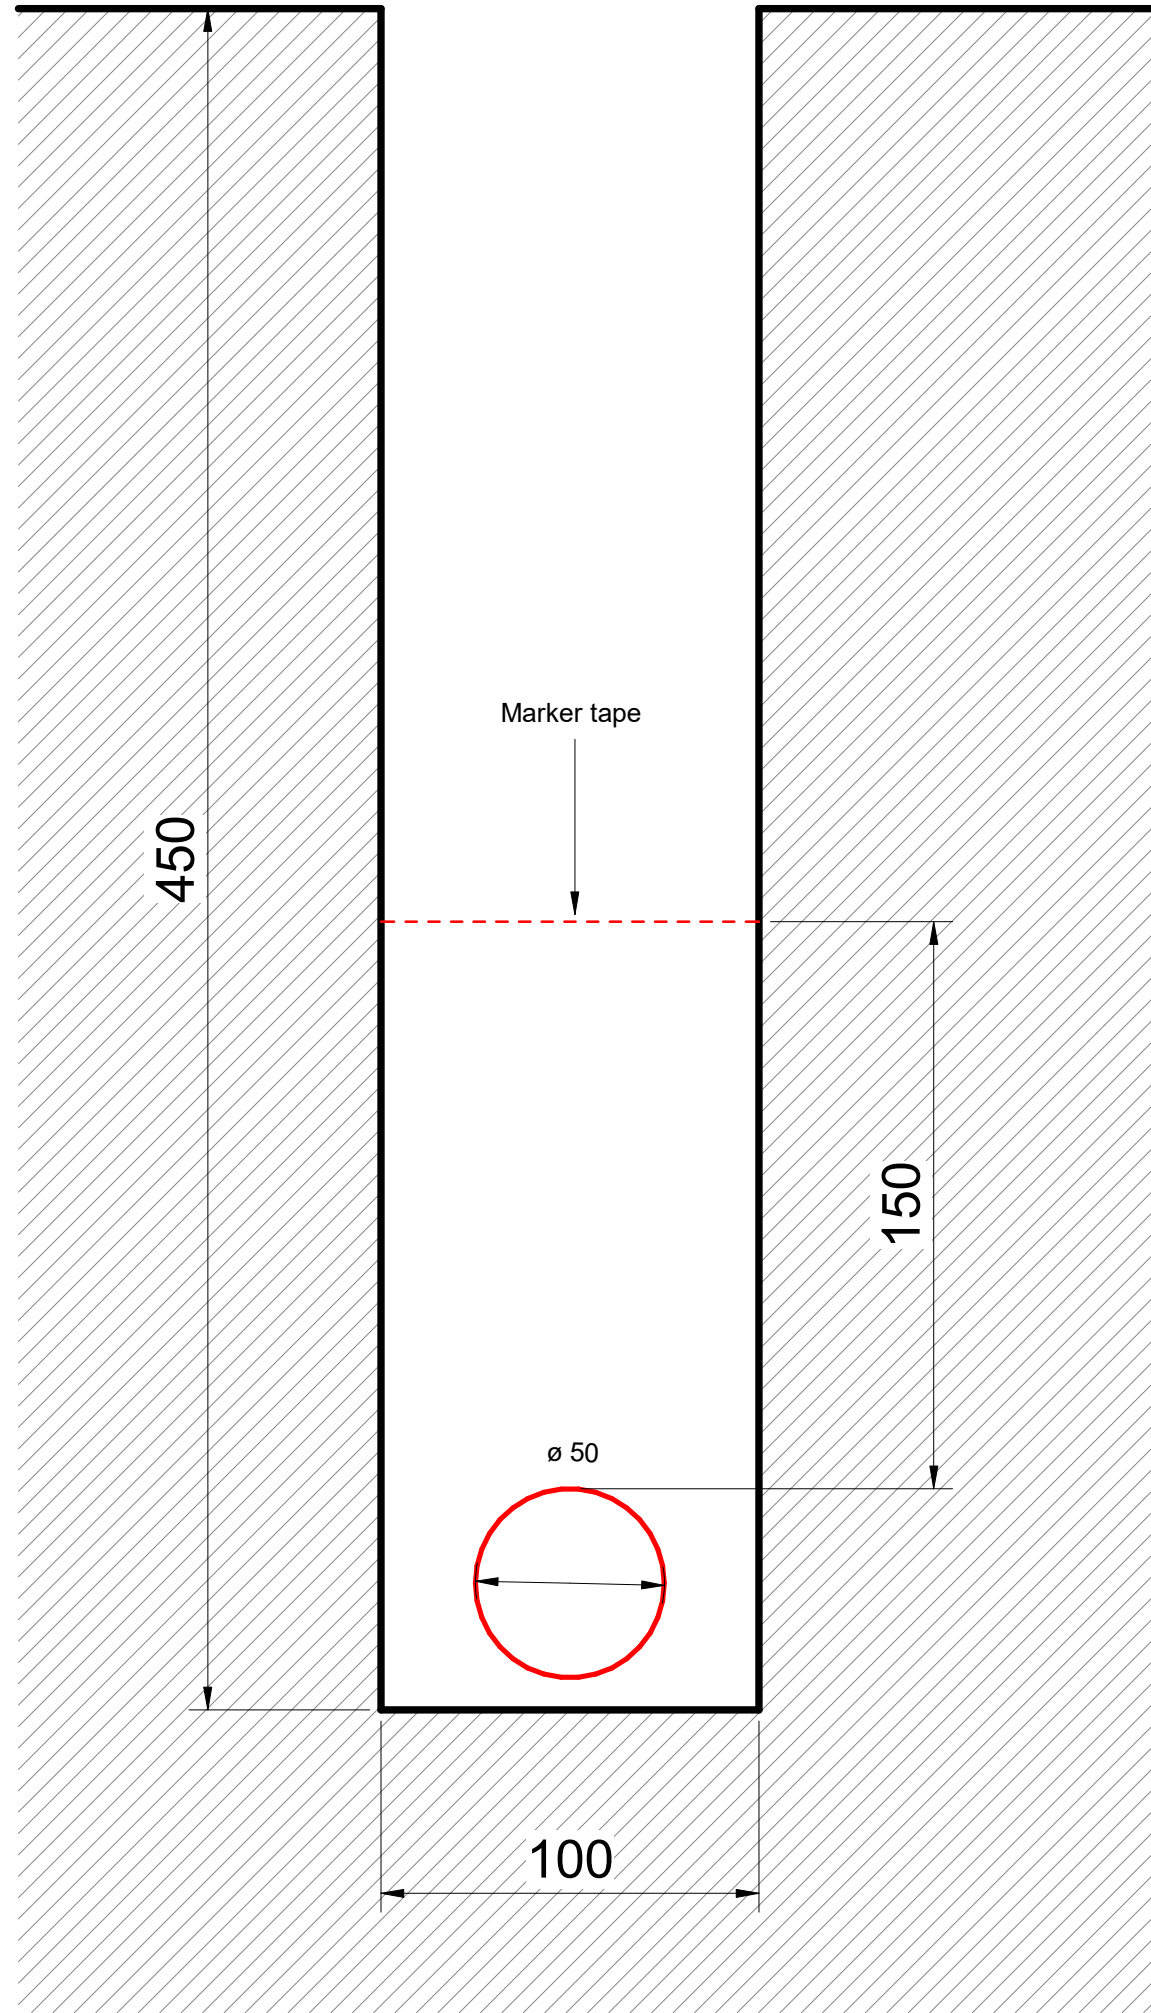

Power Ducting Section
1 : 2

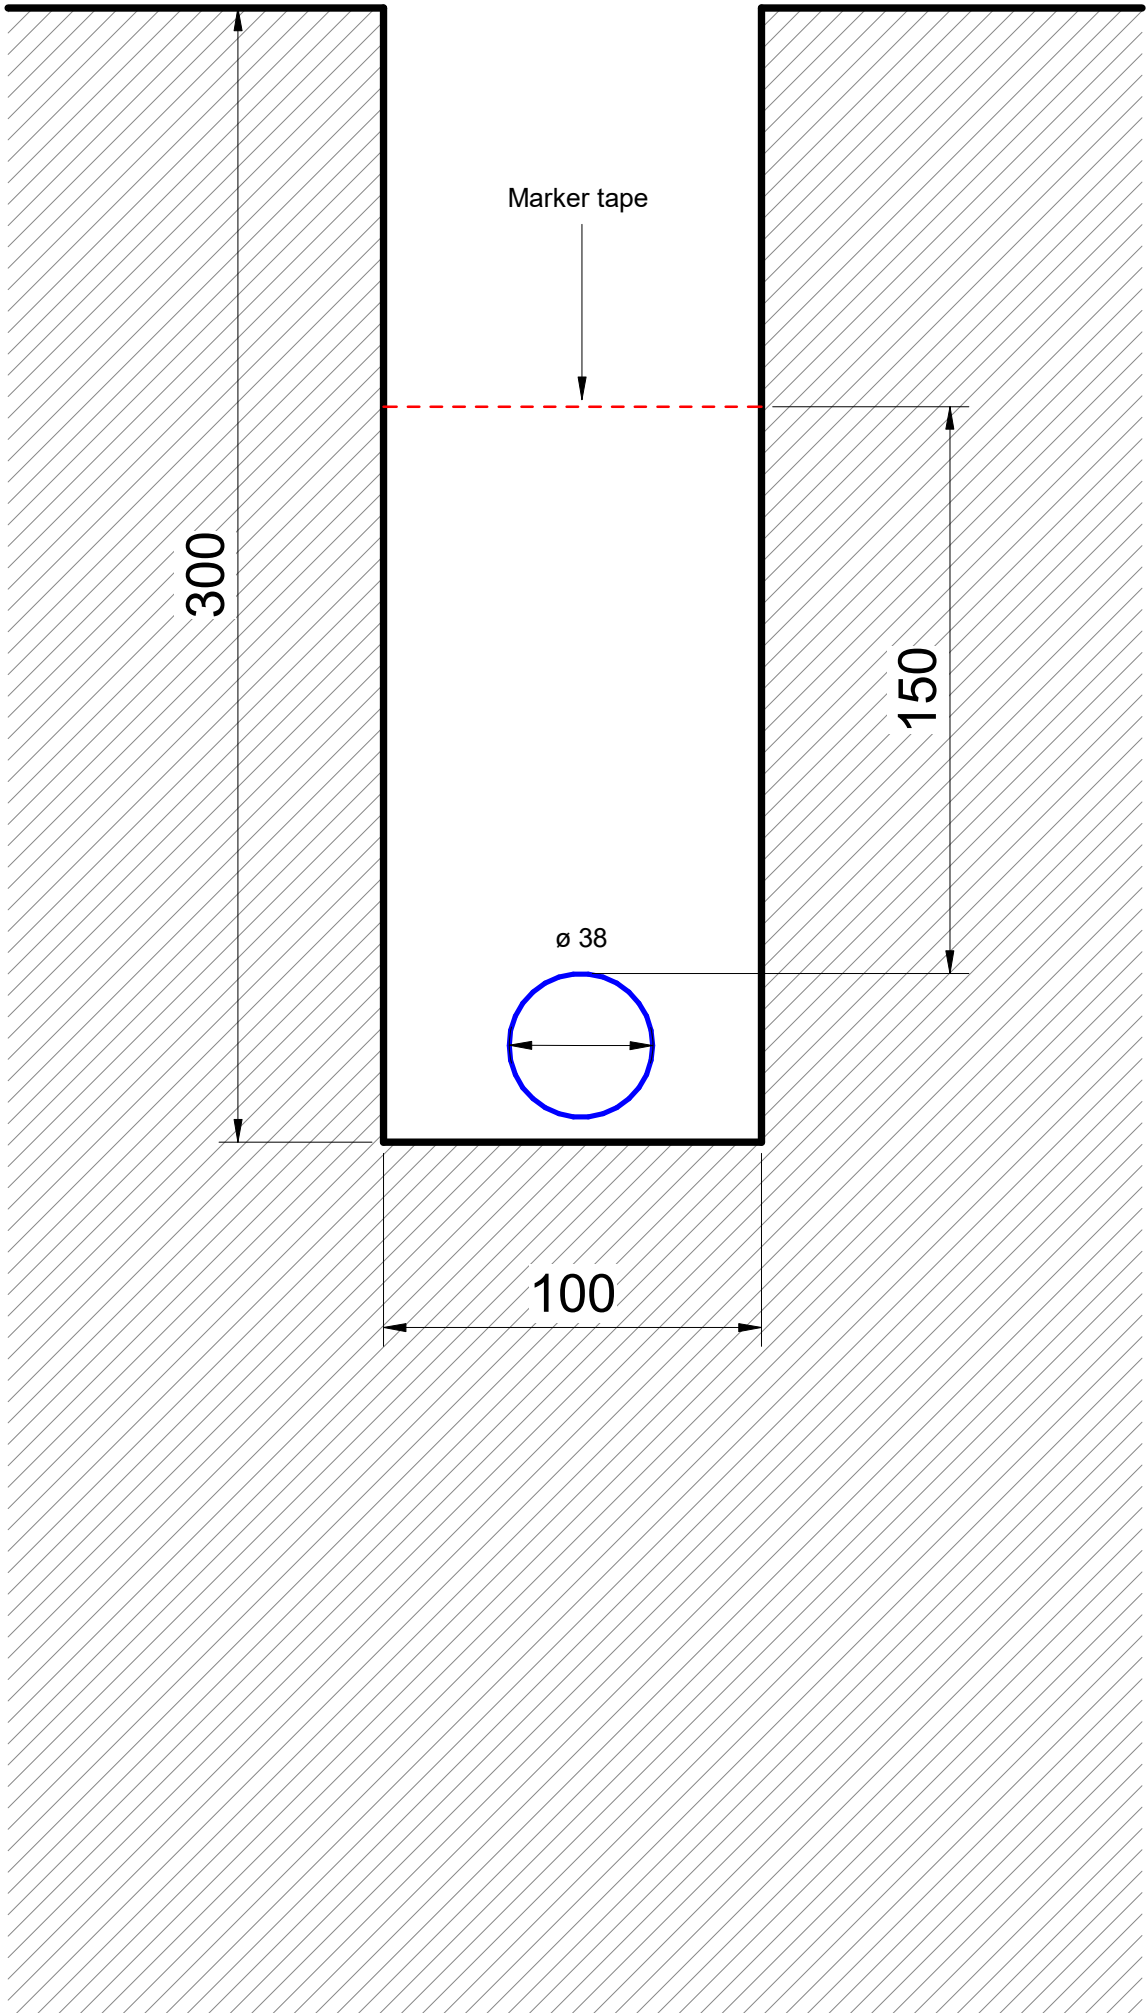

Data Only Ducting Section
1 : 2

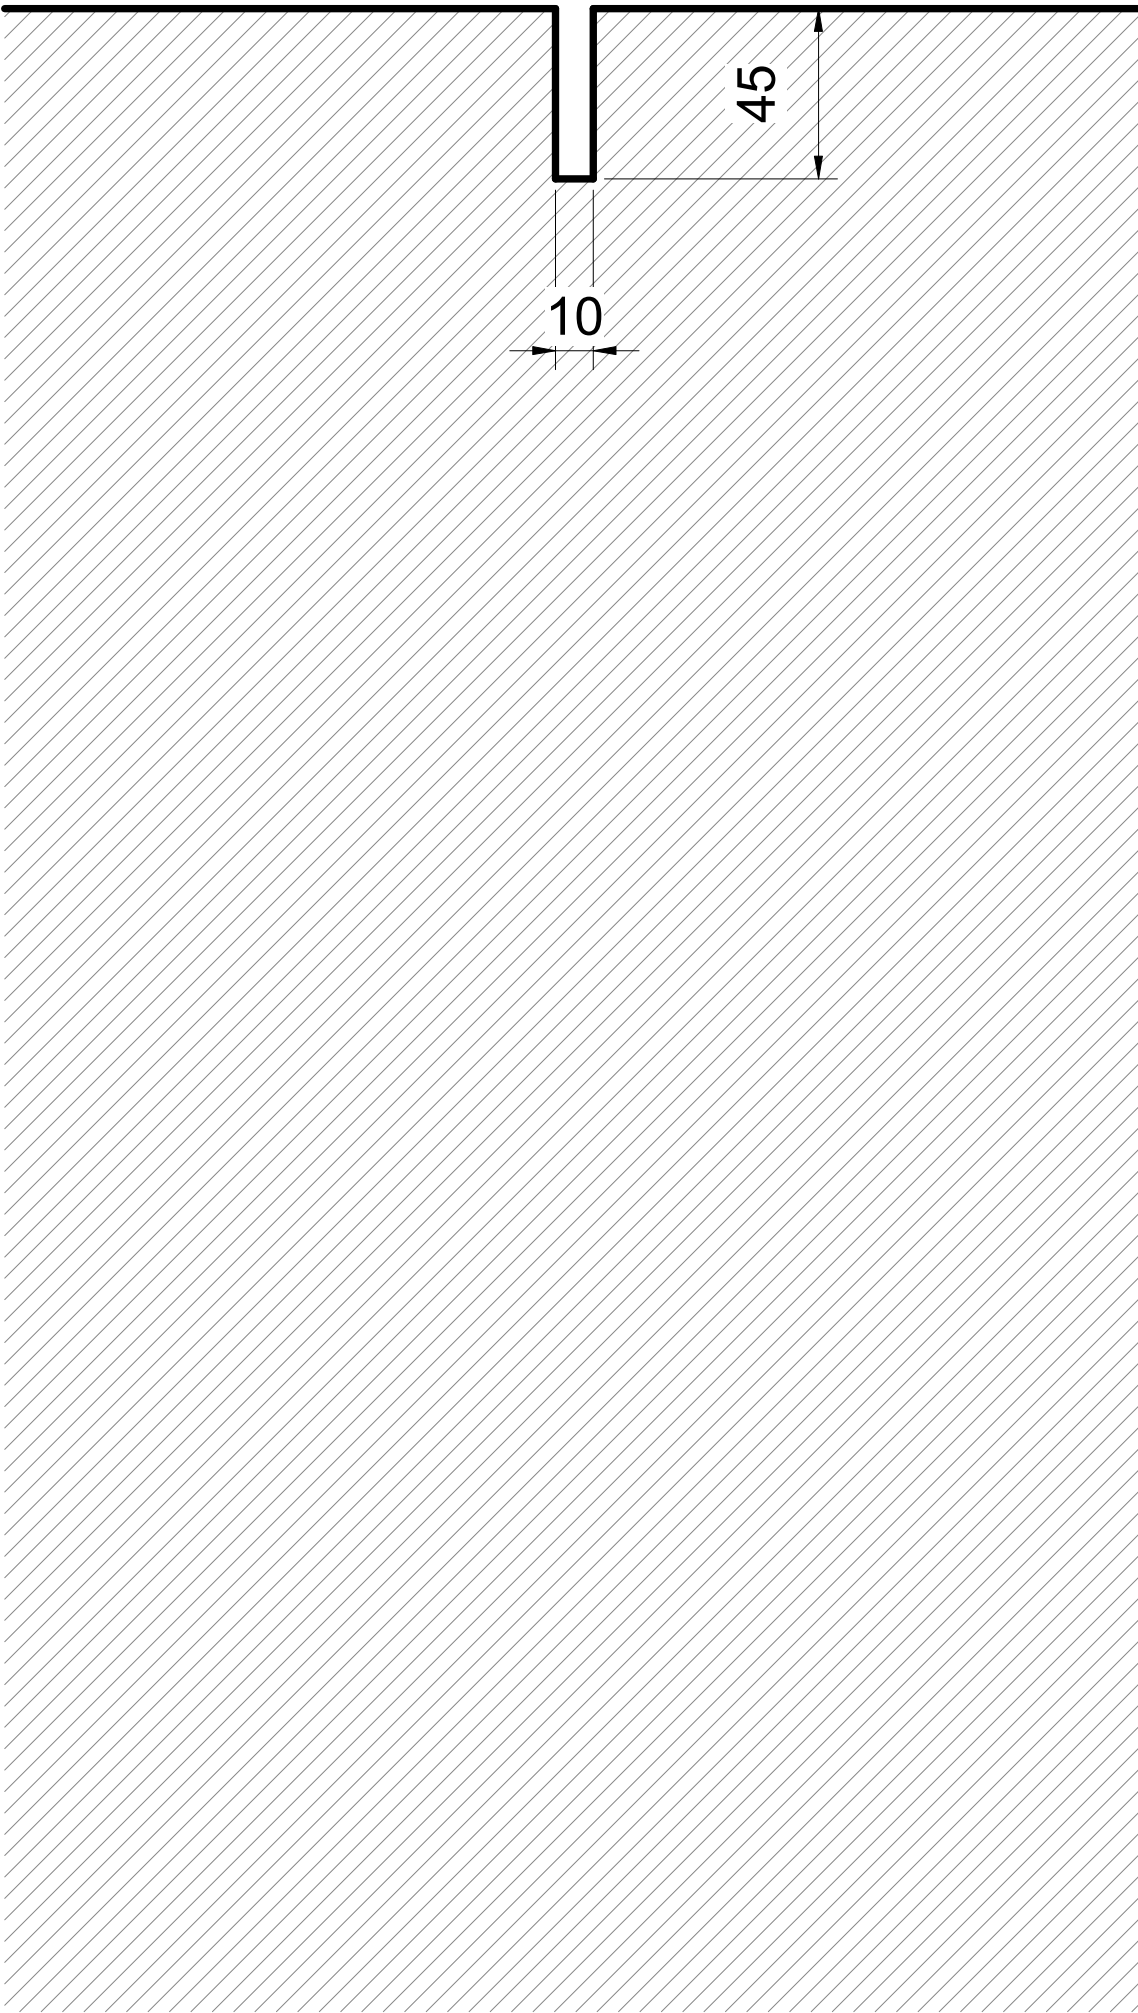

Data Slot Cut Section
1 : 2