


Rev:	Description:	By:	Date:
------	--------------	-----	-------

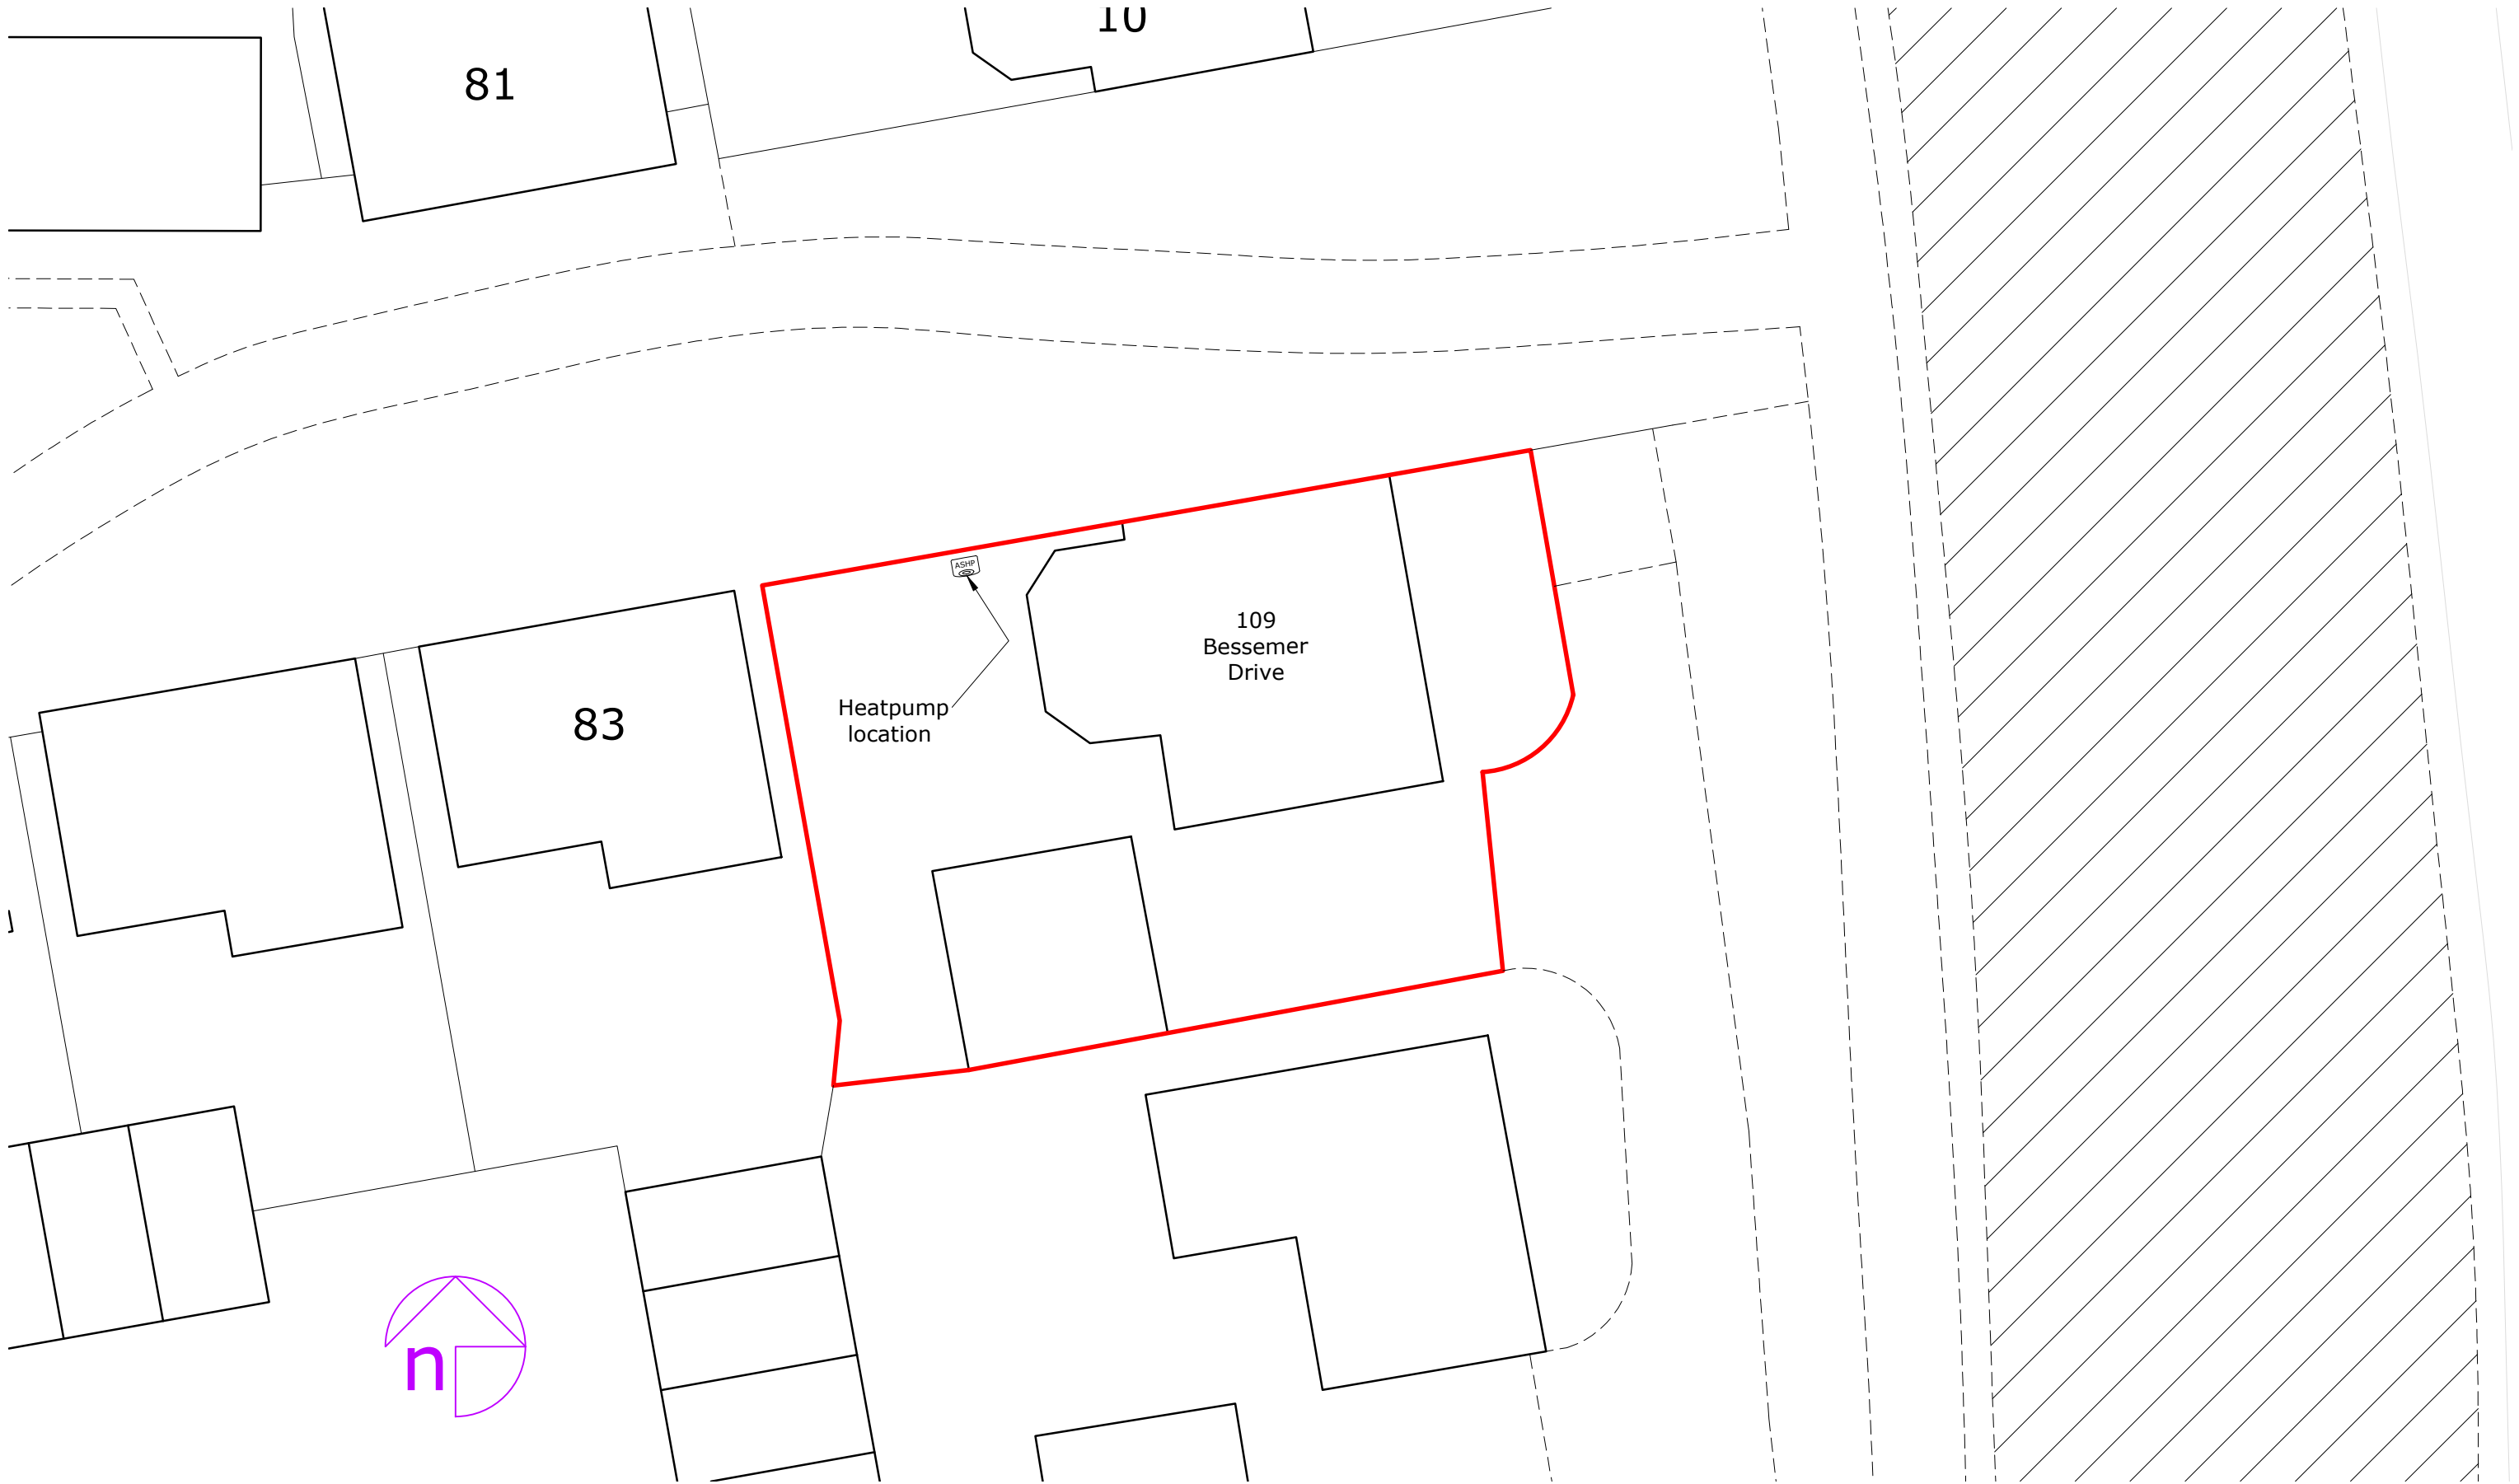

octopusenergy
services

Accredited by:



Client/Project: Gary Maslin 109 Bessemer Drive Newport NP19 4TN	Project status: PLANNING (installation of air source heat pump)
	Drawing title: Site plan as proposed

Scale: 1:200	Paper Size: A3	Drawn: D. Rodriguez	Checked:
Project ID: J-6EC91E86	Drawing No: 03	Revision: -	Date: 23.05.2025