


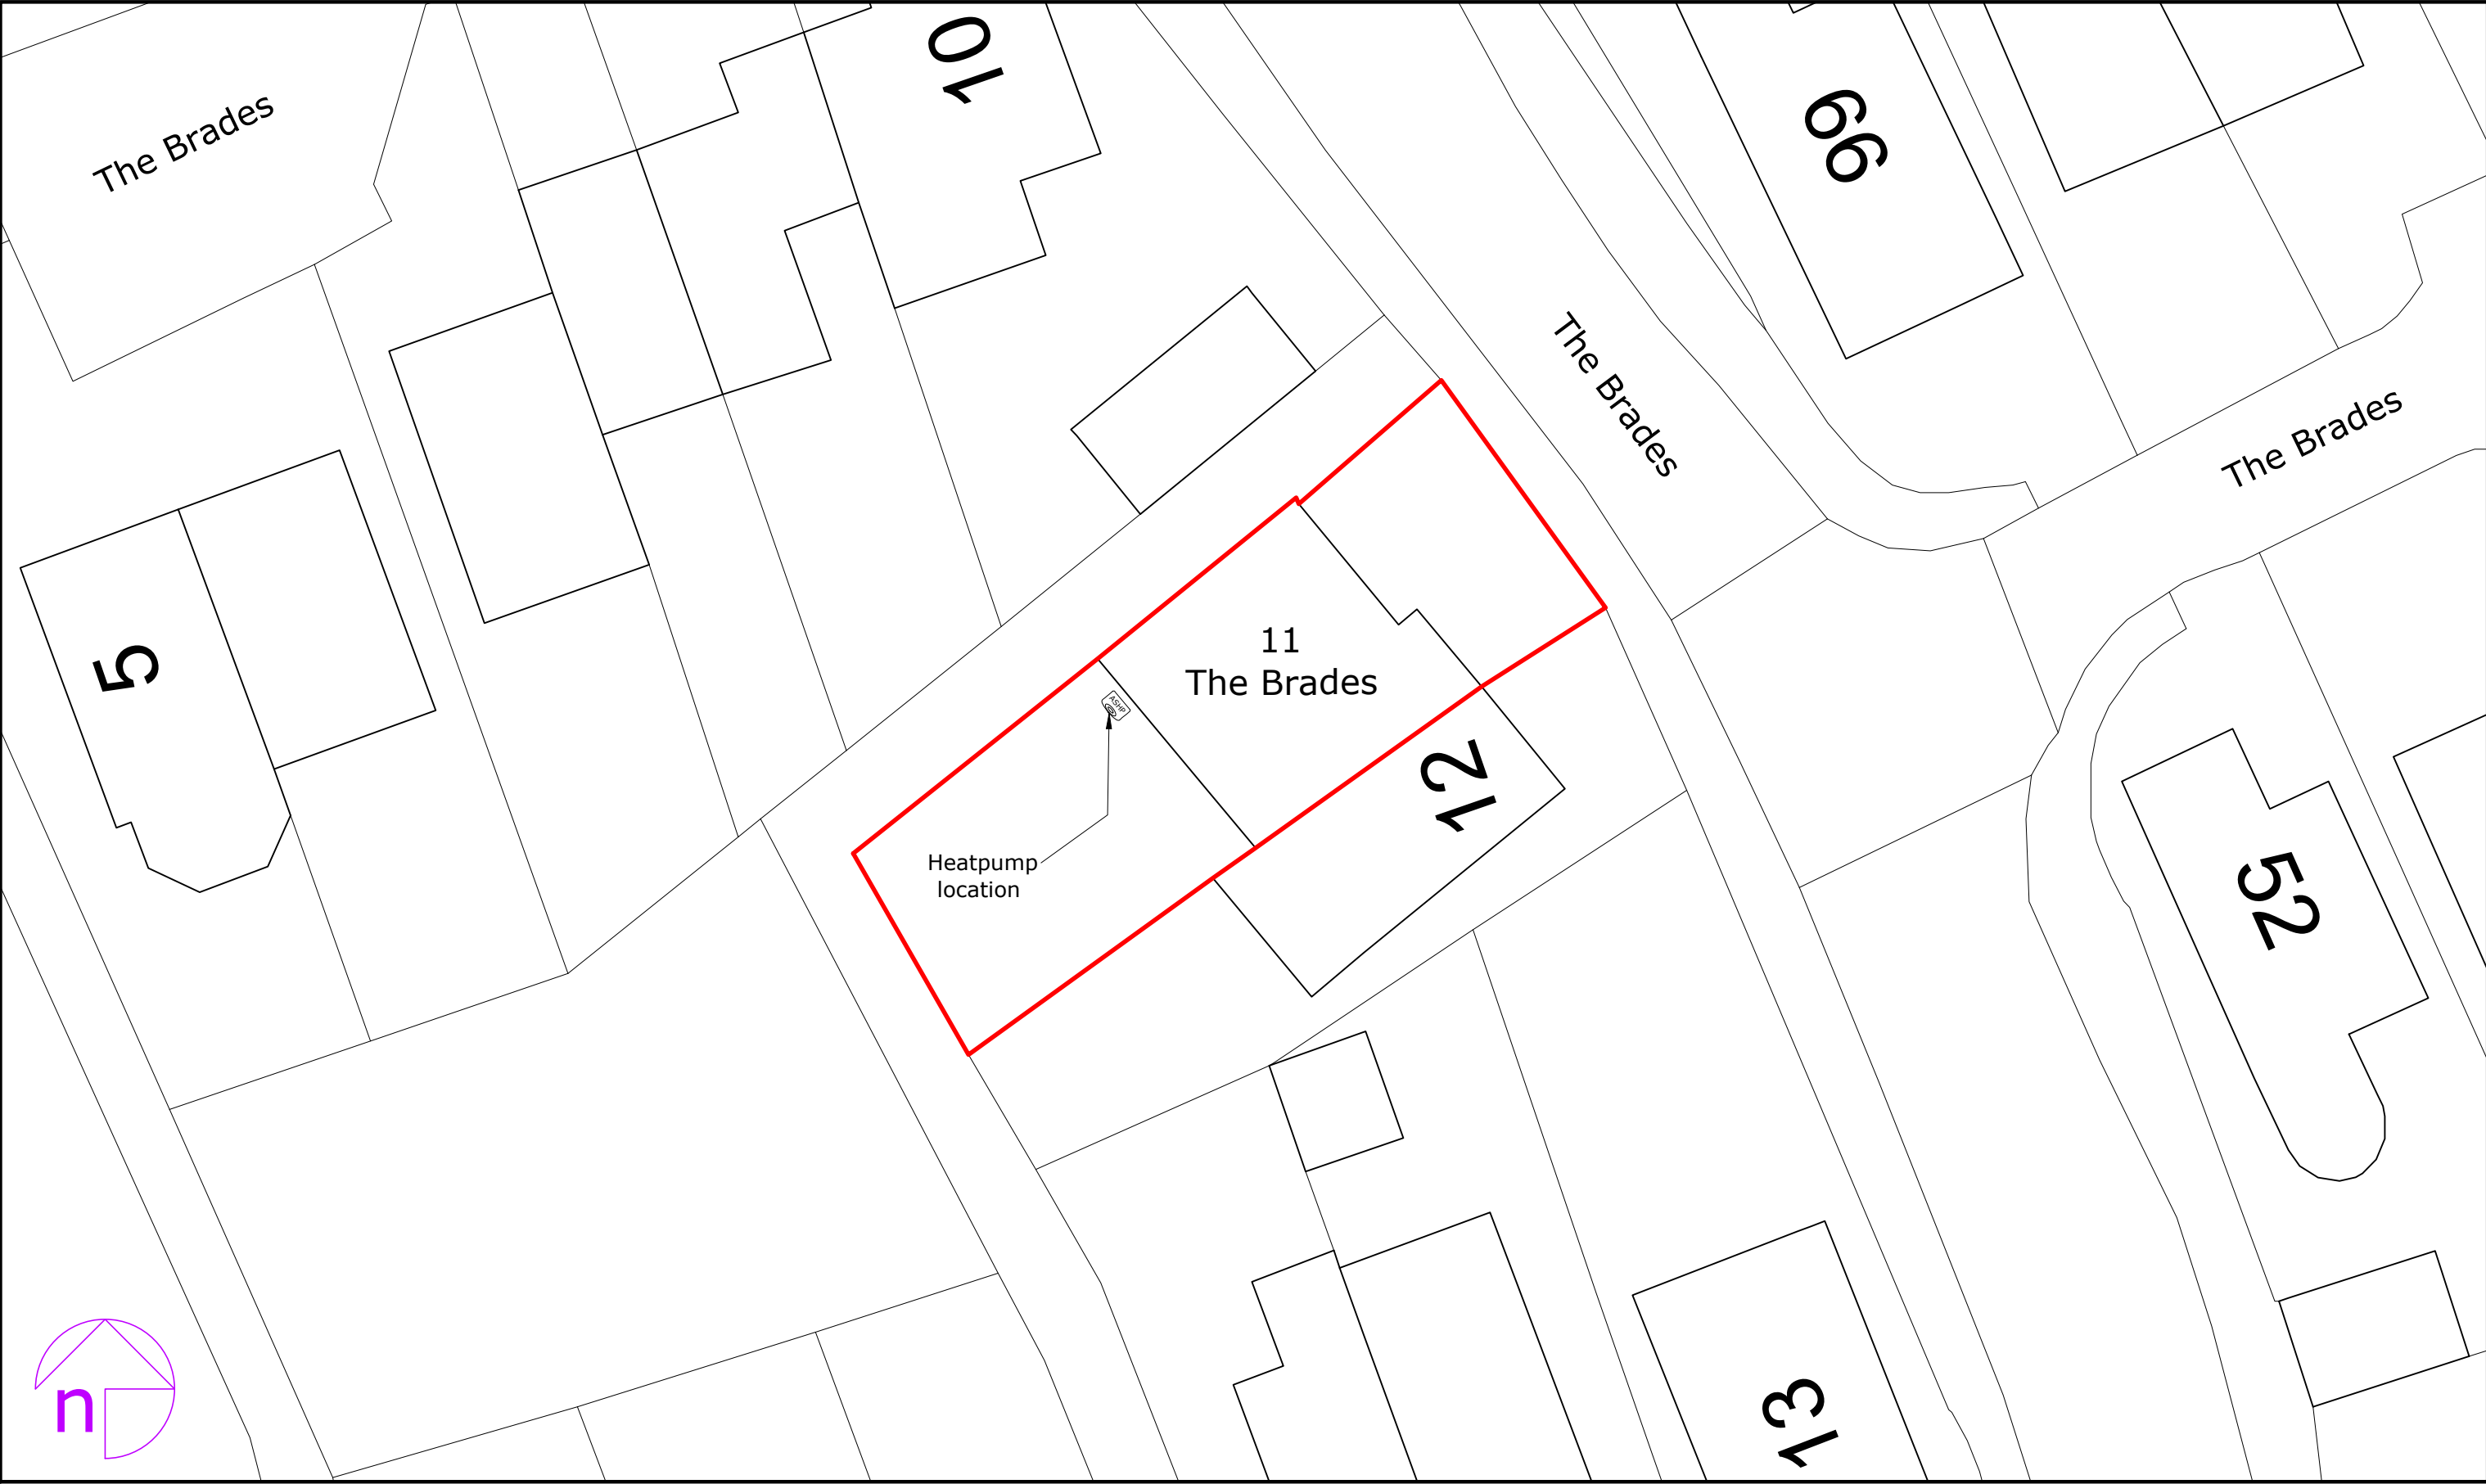

octopusenergy
services

Accredited by:



Client/Project:
David Roman
11, The Brades
Caerleon, Newport NP18 3PS

Project status:
PLANNING (installation of air source heat pump)

Drawing title:
Site plan as proposed

Scale: 1:200	Paper Size: A3	Drawn: D. Rodriguez	Checked:
Project ID: J-29F1CF5B	Drawing No: 03	Revision: -	Date: 13.03.2025